



**ADDENDUM NO. 1  
CITY OF PEORIA  
Wisconsin Avenue Roadway Improvements Nebraska to McClure  
February 5, 2024**

Re: Addendum for Bid Package, **Wisconsin Avenue Roadway Improvements**, Peoria, IL

The following shall be considered part of the Contract Documents for the subject project and shall apply to all construction there under.

This Addendum modifies the quantity of proposed relocations of light fixtures, includes additional details and notes for lighting and foundation construction, and modifies the quantity of wiring for the relocated lights. This Addendum also includes an electronic pay item spreadsheet for use in preparation of bid documents.

**PLANS**

1. Summary of Quantities (Sheets 6,7)
2. Schedule of Quantities (Sheet 13)
3. Removal Plans (Sheets 22,24)
4. Lighting Plans (Sheets 75-80)

**Specifications**

1. Reissue pages 15-17.
2. Add the following paragraph as 5.01:

Bidder has received the Excel file of the bid items provided by the City. The Excel file is provided as a convenience for the bidder, but the Bid Sheet in the formal bid package shall control. Bidder shall be responsible for providing a fully responsive bid and hereby waives any responsibility of the City for any discrepancies in the Excel file. The bid items and quantities below are the official Bid items for the project.

Signature \_\_\_\_\_ Date \_\_\_\_\_.

3. Revise bid quantities for the following items:
  - a. 81028350 UNDRGRD C PVC 2
  - b. 81702110 EC C XLP USE 1C 10
  - c. 83600200 LIGHT POLE FDN 24D
  - d. 84200500 REM LT UNIT SALV

Sincerely,

A handwritten signature in black ink that reads "Andrea Klopfenstein".

Andrea Klopfenstein, P.E.

CODE NO.	ITEM	UNIT	TOTAL QUANTITY	CONSTRUCTION CODE - 0004 ROADWAY	CONSTRUCTION CODE - 0044 DRAINAGE	CONSTRUCTION CODE - 0043 LIGHTING
60260400	INLETS TO BE ADJUSTED WITH NEW TYPE 1 FRAME, CLOSED LID	EACH	1		1	
60500060	REMOVING INLETS	EACH	16		16	
60600605	CONCRETE CURB, TYPE B	FOOT	42	42		
60604400	COMBINATION CONCRETE CURB AND GUTTER, TYPE B-6.18	FOOT	5,374	5,374		
67100100	MOBILIZATION	L SUM	1	1		
70107025	CHANGEABLE MESSAGE SIGN	CAL DA	70	70		
* 70306120	TEMPORARY PAVEMENT MARKING - LINE 4" - TYPE III TAPE	FOOT	8,900	8,900		
* 70306210	TEMPORARY PAVEMENT MARKING - LINE 24"- TYPE III TAPE	FOOT	900	900		
72400310	REMOVE SIGN PANEL - TYPE 1	SQ FT	406	406		
* 78009004	MODIFIED URETHANE PAVEMENT MARKING - LINE 4"	FOOT	2,875	2,875		
* 78009008	MODIFIED URETHANE PAVEMENT MARKING - LINE 8"	FOOT	2,513	2,513		
* 78009024	MODIFIED URETHANE PAVEMENT MARKING - LINE 24"	FOOT	223	223		
* 81028350	UNDERGROUND CONDUIT, PVC, 2" DIA.	FOOT	350			350
* 81702110	ELECTRIC CABLE IN CONDUIT, 600V (XLP-TYPE USE) 1/C NO. 10	FOOT	6,849			6,849
* 83600200	LIGHT POLE FOUNDATION, 24" DIAMETER	FOOT	27			27

\* SPECIALTY ITEMS

DESIGNED - RSS 12/12/2023 12:00:00 AM  
 DRAWN - JCL 12/12/2023 12:00:00 AM  
 REVIEWED - JFC 1/19/2024 12:00:00 AM

MODEL - 23L0004  
 FILE NAME - R23Joba23L0007\CAD\Road\Sheet\23L0004.dgn

Final	USER NAME	DESIGNED -	RSS	REVISED -	2/5/2024
		DRAWN -	JCL	REVISED -	
	PLOT SCALE	CHECKED -	JFC	REVISED -	
	PLOT DATE	DATE -	1/19/2024 12:00:00 AM	REVISED -	

**CITY OF PEORIA**

**WISCONSIN AVENUE NEBRASKA TO MCCLURE  
 SUMMARY OF QUANTITIES**

SCALE: N.T.S. SHEET OF SHEETS STA. TO STA.

F.A.U. RTE.	SECTION	COUNTY	TOTAL SHEETS	SHEET NO.
6599	23L0007	PEORIA	123	6
CONTRACT NO.				
ILLINOIS FED. AID PROJECT				

CODE NO.	ITEM	UNIT	TOTAL QUANTITY	CONSTRUCTION CODE - 0004 ROADWAY	CONSTRUCTION CODE - 0044 DRAINAGE	CONSTRUCTION CODE - 0043 LIGHTING
* 84200500	REMOVAL OF LIGHTING UNIT, SALVAGE	EACH	9			9 <sup>Δ</sup>
K1005481	SHREDDED BARK MULCH 3"	SQ YD	93	93		
Z0012455	CONCRETE STEP REMOVAL	EACH	10	10		
* Z0013798	CONSTRUCTION LAYOUT	L SUM	1	1		
Z0016702	DETOUR SIGNING	L SUM	1	1		
Z0019500	DRYWELL	EACH	4		4	
Z0042300	PORTLAND CEMENT CONCRETE SIDEWALK CURB	FOOT	188	188		
Z0056646	STORM SEWERS, TYPE 1, WATER MAIN QUALITY PIPE, 10"	FOOT	30		30	
Z0056648	STORM SEWERS, TYPE 1, WATER MAIN QUALITY PIPE, 12"	FOOT	845		845	
Z0075496	CONCRETE RETAINING WALL REMOVAL	FOOT	168	168		
Z0076600	TRAINEES	HOURL	1,000	1,000		
Z0076604	TRAINEES TRAINING PROGRAM GRADUATE	HOURL	1,000	1,000		
X5220102	RETAINING WALL REMOVAL	FOOT	80	80		
X6020082	INLETS, TYPE G-1	EACH	10		10	
X6026200	INLETS TO BE ADJUSTED (SPECIAL)	EACH	3		3	

\* SPECIALTY ITEMS



DESIGNED - RSS 12/12/2023 12:00:00 AM  
 DRAWN - JCL 12/12/2023 12:00:00 AM  
 REVIEWED - JFC 1/19/2024 12:00:00 AM

MODEL - 14-50005  
 FILE NAME - R230323210007/CAD/RevisedSheet14-50005.dgn

Final	USER NAME	DESIGNED -	RSS	REVISED -	<sup>Δ</sup> 2/5/2024
		DRAWN -	JCL	REVISED -	
	PLOT SCALE	CHECKED -	JFC	REVISED -	
	PLOT DATE	DATE -	1/19/2024 12:00:00 AM	REVISED -	

**CITY OF PEORIA**

**WISCONSIN AVENUE NEBRASKA TO MCCLURE  
 SUMMARY OF QUANTITIES**

SCALE: N.T.S. SHEET OF SHEETS STA. TO STA.

F.A.U. RTE.	SECTION	COUNTY	TOTAL SHEETS	SHEET NO.
6599		PEORIA	123	7
23L0007		CONTRACT NO.		
ILLINOIS FED. AID PROJECT				

STRUCTURE ADJUSTMENT SCHEDULE								
LOCATION		EXISTING RIM ELEVATION	PROPOSED RIM ELEVATION	60260100 INLETS TO BE ADJUSTED	60260400 INLETS TO BE ADJUSTED WITH NEW TYPE 1 FRAME, CLOSED LID	X6026050 SANITARY MANHOLES TO BE ADJUSTED	X6026200 INLETS TO BE ADJUSTED (SPECIAL)	X8140115 HANDHOLE TO BE ADJUSTED
STATION	OFFSET			EACH	EACH	EACH	EACH	EACH
WISCONSIN AVENUE								
23+45.47	2.00' RT	639.08	638.90			1		
27+01.53	36.64' LT	633.66	633.43				1	
27+16.73	23.68' RT	633.02	633.30				1	
27+17.06	12.01' LT	633.57	633.43			1		
27+30.84	27.91' RT	633.64	633.30					1
27+31.85	36.89' LT	633.06	632.94				1	
27+51.54	24.45' LT	633.69	633.73					1
27+71.26	34.54' RT	632.81	632.60			1		
33+03.38	2.09' RT	625.34	625.38			1		
34+82.62	3.52' RT	624.34	624.53			1		
34+82.69	18.27' RT	624.14	624.29		1			
35+31.17	40.45' RT	624.20	623.95			1		
38+40.52	2.34' RT	623.55	623.25			1		
41+49.97	3.43' RT	624.49	624.14			1		
41+69.63	30.92' LT	624.33	624.22			1		
41+88.43	15.00' LT	623.67	624.05	1				
46+26.98	3.69' RT	628.44	628.68			1		
46+75.89	3.51' RT	629.03	629.37			1		
49+16.17	3.18' RT	633.18	632.92			1		
50+01.18	3.49' RT	634.36	634.32			1		
TOTAL				1	1	13	3	2

TREE PROTECTION SCHEDULE		
LOCATION	20101100 TREE TRUNK PROTECTION	
STATION	OFFSET	EACH
WISCONSIN AVENUE		
27+92.22	52.58' RT	1
28+21.86	28.31' RT	1
28+45.83	28.09' RT	1
28+69.31	28.30' RT	1
28+92.75	27.73' RT	1
29+16.29	27.85' RT	1
29+63.36	28.06' RT	1
29+86.88	28.79' RT	1
30+10.54	28.50' RT	1
31+46.30	24.00' RT	1
31+68.62	23.90' RT	1
31+97.95	23.73' RT	1
32+23.82	22.91' RT	1
32+51.54	22.72' RT	1
32+78.19	23.25' RT	1
33+06.47	22.43' RT	1
33+36.21	23.14' RT	1
33+62.94	22.56' RT	1
33+88.02	23.01' RT	1
34+14.82	22.86' RT	1
34+39.43	22.67' RT	1
34+64.61	22.72' RT	1
34+89.56	22.52' RT	1
TOTAL		23

INLET REMOVAL SCHEDULE		
LOCATION	60500060 REMOVING INLETS	
STATION	OFFSET	EACH
WISCONSIN AVENUE		
34+52.38	13.62' LT	1
34+68.03	33.50' LT	1
34+97.96	33.75' LT	1
35+45.55	19.06' RT	1
38+16.65	11.58' LT	1
38+40.45	18.86' RT	1
38+58.21	14.58' LT	1
41+30.58	21.45' RT	1
41+47.52	17.85' LT	1
41+74.12	22.21' RT	1
46+10.34	20.72' RT	1
46+45.00	20.55' RT	1
46+68.60	12.06' LT	1
46+92.30	10.22' LT	1
50+21.07	13.32' LT	1
50+21.24	20.66' RT	1
TOTAL		16

SIGN REMOVAL SCHEDULE		
LOCATION	72400310 REMOVE SIGN PANEL - TYPE 1	
BEGIN STATION	END STATION	SQ FT
WISCONSIN AVENUE		
22+50.00	28+50.00	113
28+50.00	33+50.00	53
33+50.00	39+00.00	69
39+00.00	44+00.00	55
44+00.00	49+00.00	54
49+00.00	54+00.00	62
TOTAL		406

LIGHTING REMOVAL SCHEDULE		
LOCATION	84200500 REMOVAL OF LIGHTING UNIT, SALVAGE	
STATION	OFFSET	EACH
WISCONSIN AVENUE		
27+37.87	17.52' LT	1
34+52.41	21.29' LT	1
35+53.48	23.21' RT	1
38+06.20	19.18' LT	1
40+20.26	18.69' LT	1
41+29.91	19.66' LT	1
48+89.36	25.57' RT	1
48+97.20	18.95' LT	1
49+77.60	27.73' LT	1
TOTAL		9

LIGHTING SCHEDULE		
LOCATION	83600200 LIGHT POLE FOUNDATION, 24" DIAMETER	
STATION	OFFSET	FOOT
WISCONSIN AVENUE		
27+38.06	21.22' LT	3
34+51.45	24.60' LT	3
35+51.76	30.06' RT	3
37+98.06	20.88' LT	3
40+20.32	19.45' LT	3
41+26.18	20.88' LT	3
48+89.43	26.74' RT	3
48+97.30	19.29' LT	3
49+70.21	24.13' LT	3
TOTAL		27

ELECTRIC CABLE SCHEDULE					
LOCATION		81028350 UNDERGROUND CONDUIT, PVC, 2" DIA.	81702110 ELECTRIC CABLE IN CONDUIT, 600V (XLP-TYPE USE) 1/2" NO. 10		
WISCONSIN AVENUE		FOOT	FOOT		
BEGIN STATION	BEGIN OFFSET	END STATION	END OFFSET		
25+89.42	24.44' LT	27+38.06	21.22' LT	25	522
27+38.06	21.22' LT	28+58.45	24.19' LT	25	435
33+45.86	21.31' LT	34+51.45	24.60' LT	25	390
34+01.24	21.84' RT	35+51.76	30.06' RT	25	528
34+51.45	24.60' LT	36+27.92	19.38' LT	25	531
35+51.76	30.06' RT	36+51.41	26.47' RT	25	375
36+93.06	19.28' LT	37+98.06	20.88' LT	25	390
37+98.06	20.88' LT	40+20.32	19.45' LT	25	666
40+20.32	19.45' LT	41+26.18	20.88' LT	25	318
41+26.18	20.88' LT	42+74.53	19.38' LT	25	519
47+75.73	26.22' RT	48+89.43	26.74' RT	25	417
48+11.01	19.91' LT	48+97.30	19.29' LT	25	258
48+70.21	24.13' LT			50	1500
TOTAL				350	6849



Final	USER NAME	DESIGNED - RSS	REVISED -  2/5/2024
		DRAWN - JCL	REVISED -
	PLOT SCALE	CHECKED - JFC	REVISED -
	PLOT DATE	DATE - 1/19/2024 12:00:00 AM	REVISED -

**CITY OF PEORIA**

**WISCONSIN AVENUE NEBRASKA TO MCCLURE SCHEDULES**

SCALE: N.T.S. SHEET OF SHEETS STA. TO STA.

F.A.U. RTE.	SECTION	COUNTY	TOTAL SHEETS	SHEET NO.
6599		PEORIA	123	13
23L0007		CONTRACT NO.		
		ILLINOIS FED. AID PROJECT		

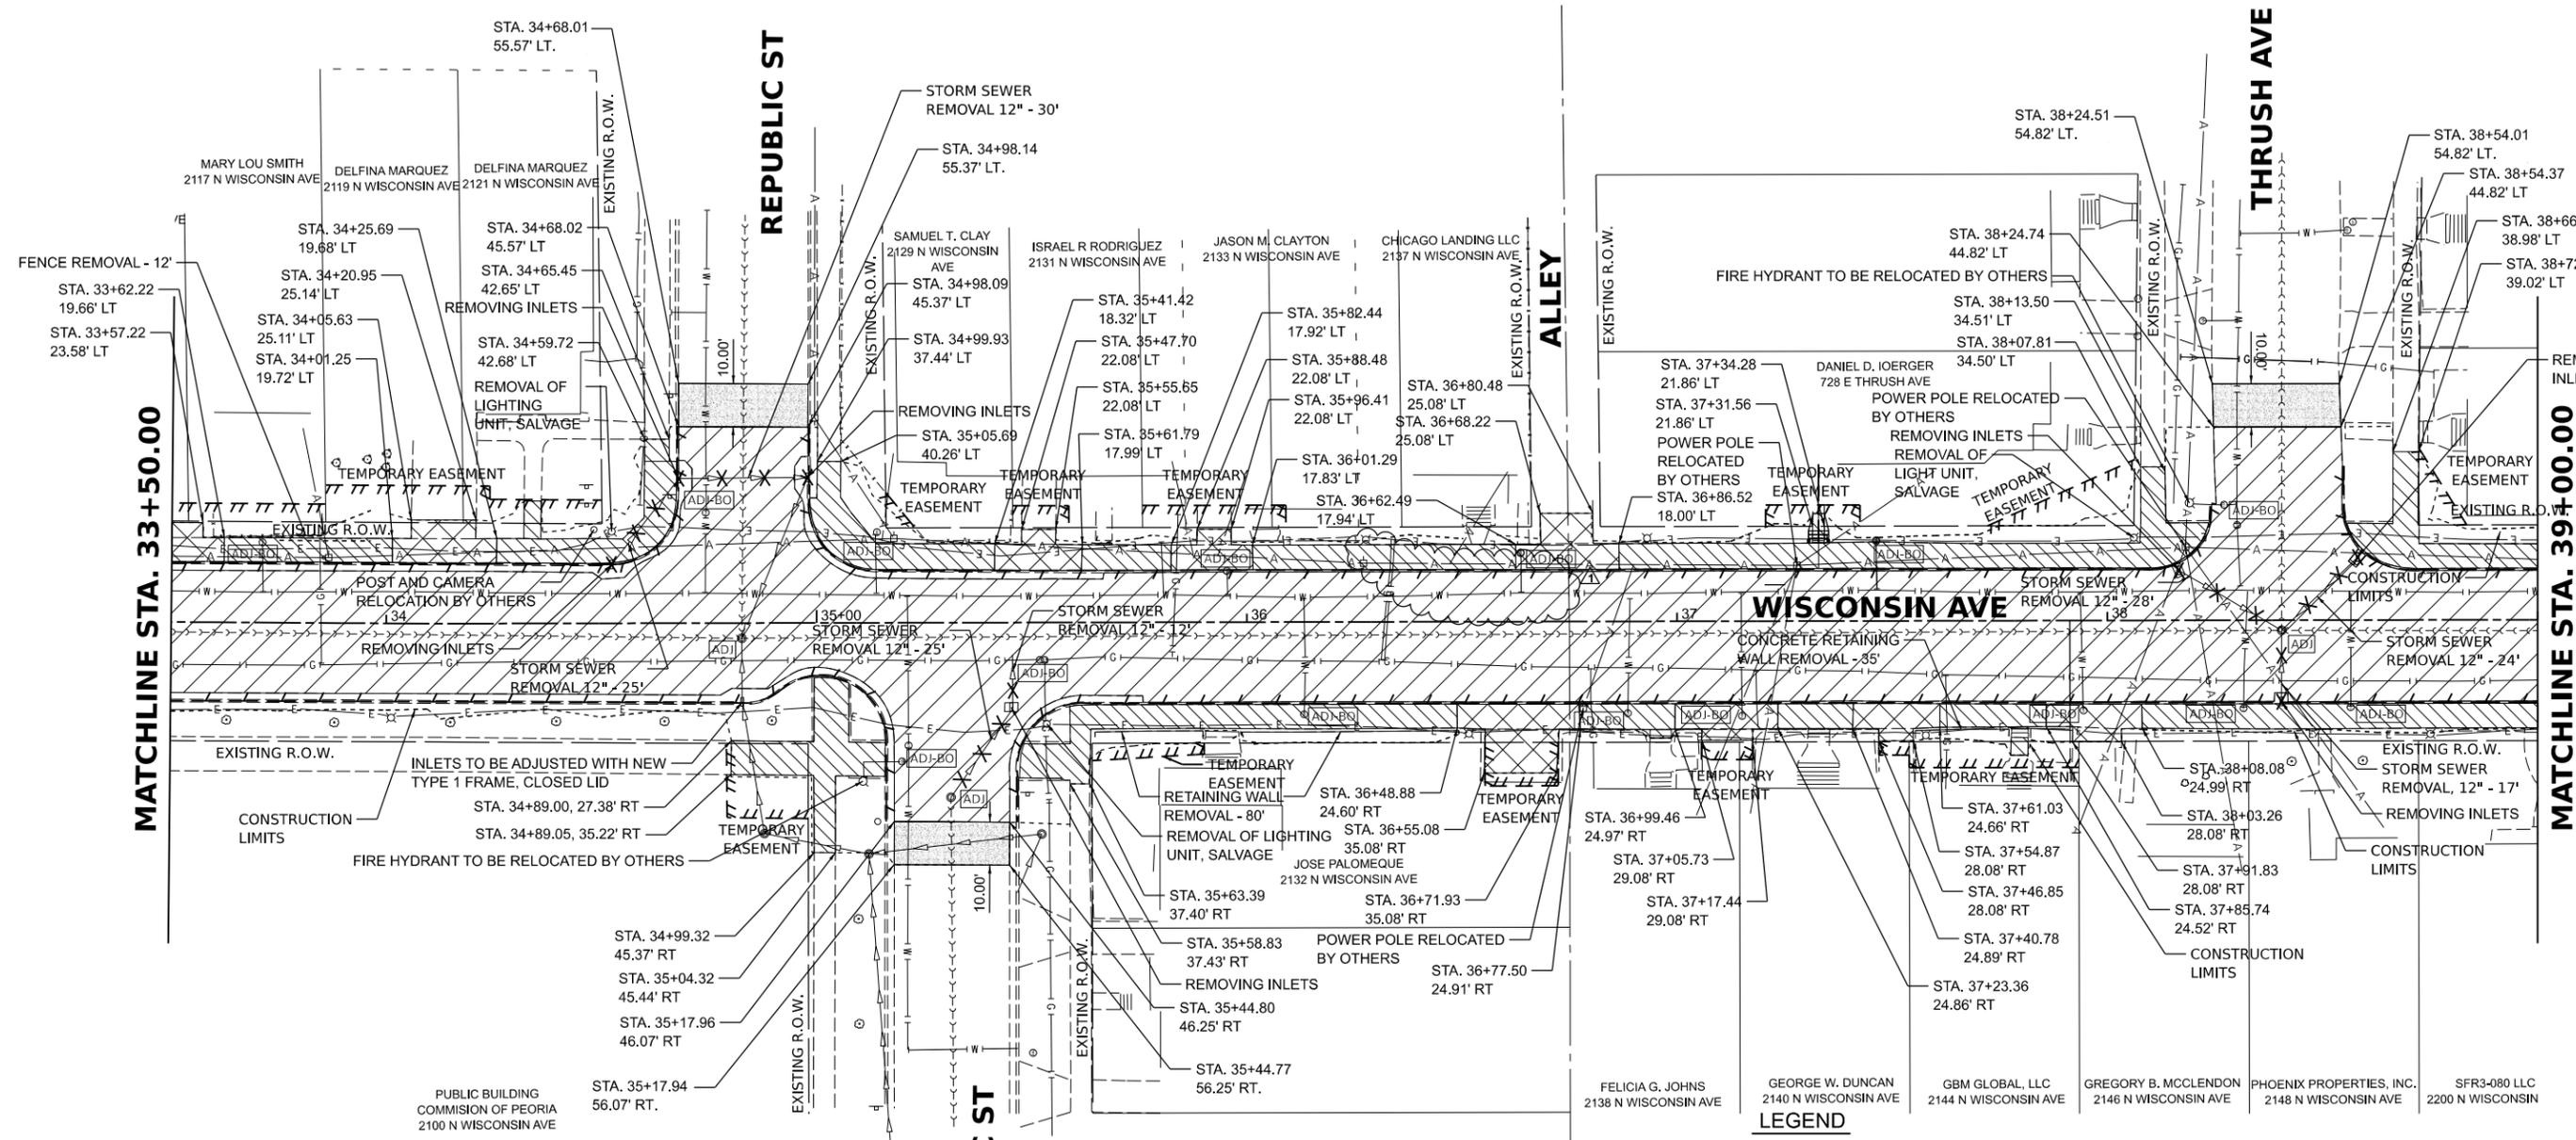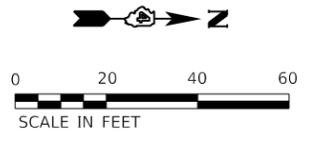

**MATCHLINE STA. 33+50.00**

**MATCHLINE STA. 39+00.00**

**LEGEND**

	PAVEMENT REMOVAL		COMBINATION CURB AND GUTTER REMOVAL
	DRIVEWAY PAVEMENT REMOVAL		STORM SEWER REMOVAL
	SIDEWALK REMOVAL		REMOVING INLETS
	HOT-MIX ASPHALT SURFACE REMOVAL, BUTT JOINT		HANDHOLE REMOVAL
	BRICK PAVEMENT REMOVAL AND SALVAGE		UTILITY FEATURE TO BE ADJUSTED
	REMOVE AND RESET BRICK PAVEMENT		UTILITY FEATURE TO BE ADJUSTED BY OTHERS

WATER AND GAS VALVES TO BE ADJUSTED BY OTHERS.

DESIGNED - RSS 12/12/2023 12:00:00 AM  
 DRAWN - JCL 12/12/2023 12:00:00 AM  
 REVIEWED - JFC 1/19/2024 12:00:00 AM

MODEL - 3d-removal3  
 FILE NAME - R230323-21-0007-CAD-ROAD-Street-removal03.dwg

Final	USER NAME	DESIGNED - RSS	REVISED -  2/5/2024
		DRAWN - JCL	REVISED -
	PLOT SCALE	CHECKED - JFC	REVISED -
	PLOT DATE	DATE - 1/19/2024 12:00:00 AM	REVISED -

 
 
**CITY OF PEORIA**


**WISCONSIN AVENUE NEBRASKA TO MCCLURE  
REMOVAL PLANS**

F.A.U. RTE. 6599	SECTION 23L0007	COUNTY PEORIA	TOTAL SHEETS 123	SHEET NO. 22
SCALE: 1" = 20'		SHEET OF SHEETS		STA. TO STA.
		ILLINOIS		FED. AID PROJECT




**LEGEND**

-  PAVEMENT REMOVAL
-  DRIVEWAY PAVEMENT REMOVAL
-  SIDEWALK REMOVAL
-  HOT-MIX ASPHALT SURFACE REMOVAL, BUTT JOINT
-  BRICK PAVEMENT REMOVAL AND SALVAGE
-  REMOVE AND RESET BRICK PAVEMENT
-  COMBINATION CURB AND GUTTER REMOVAL
-  STORM SEWER REMOVAL
-  REMOVING INLETS
-  HANDHOLE REMOVAL
-  UTILITY FEATURE TO BE ADJUSTED
-  UTILITY FEATURE TO BE ADJUSTED BY OTHERS

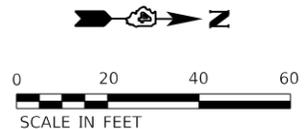

MATCHLINE STA. 44+00.00

MATCHLINE STA. 49+00.00

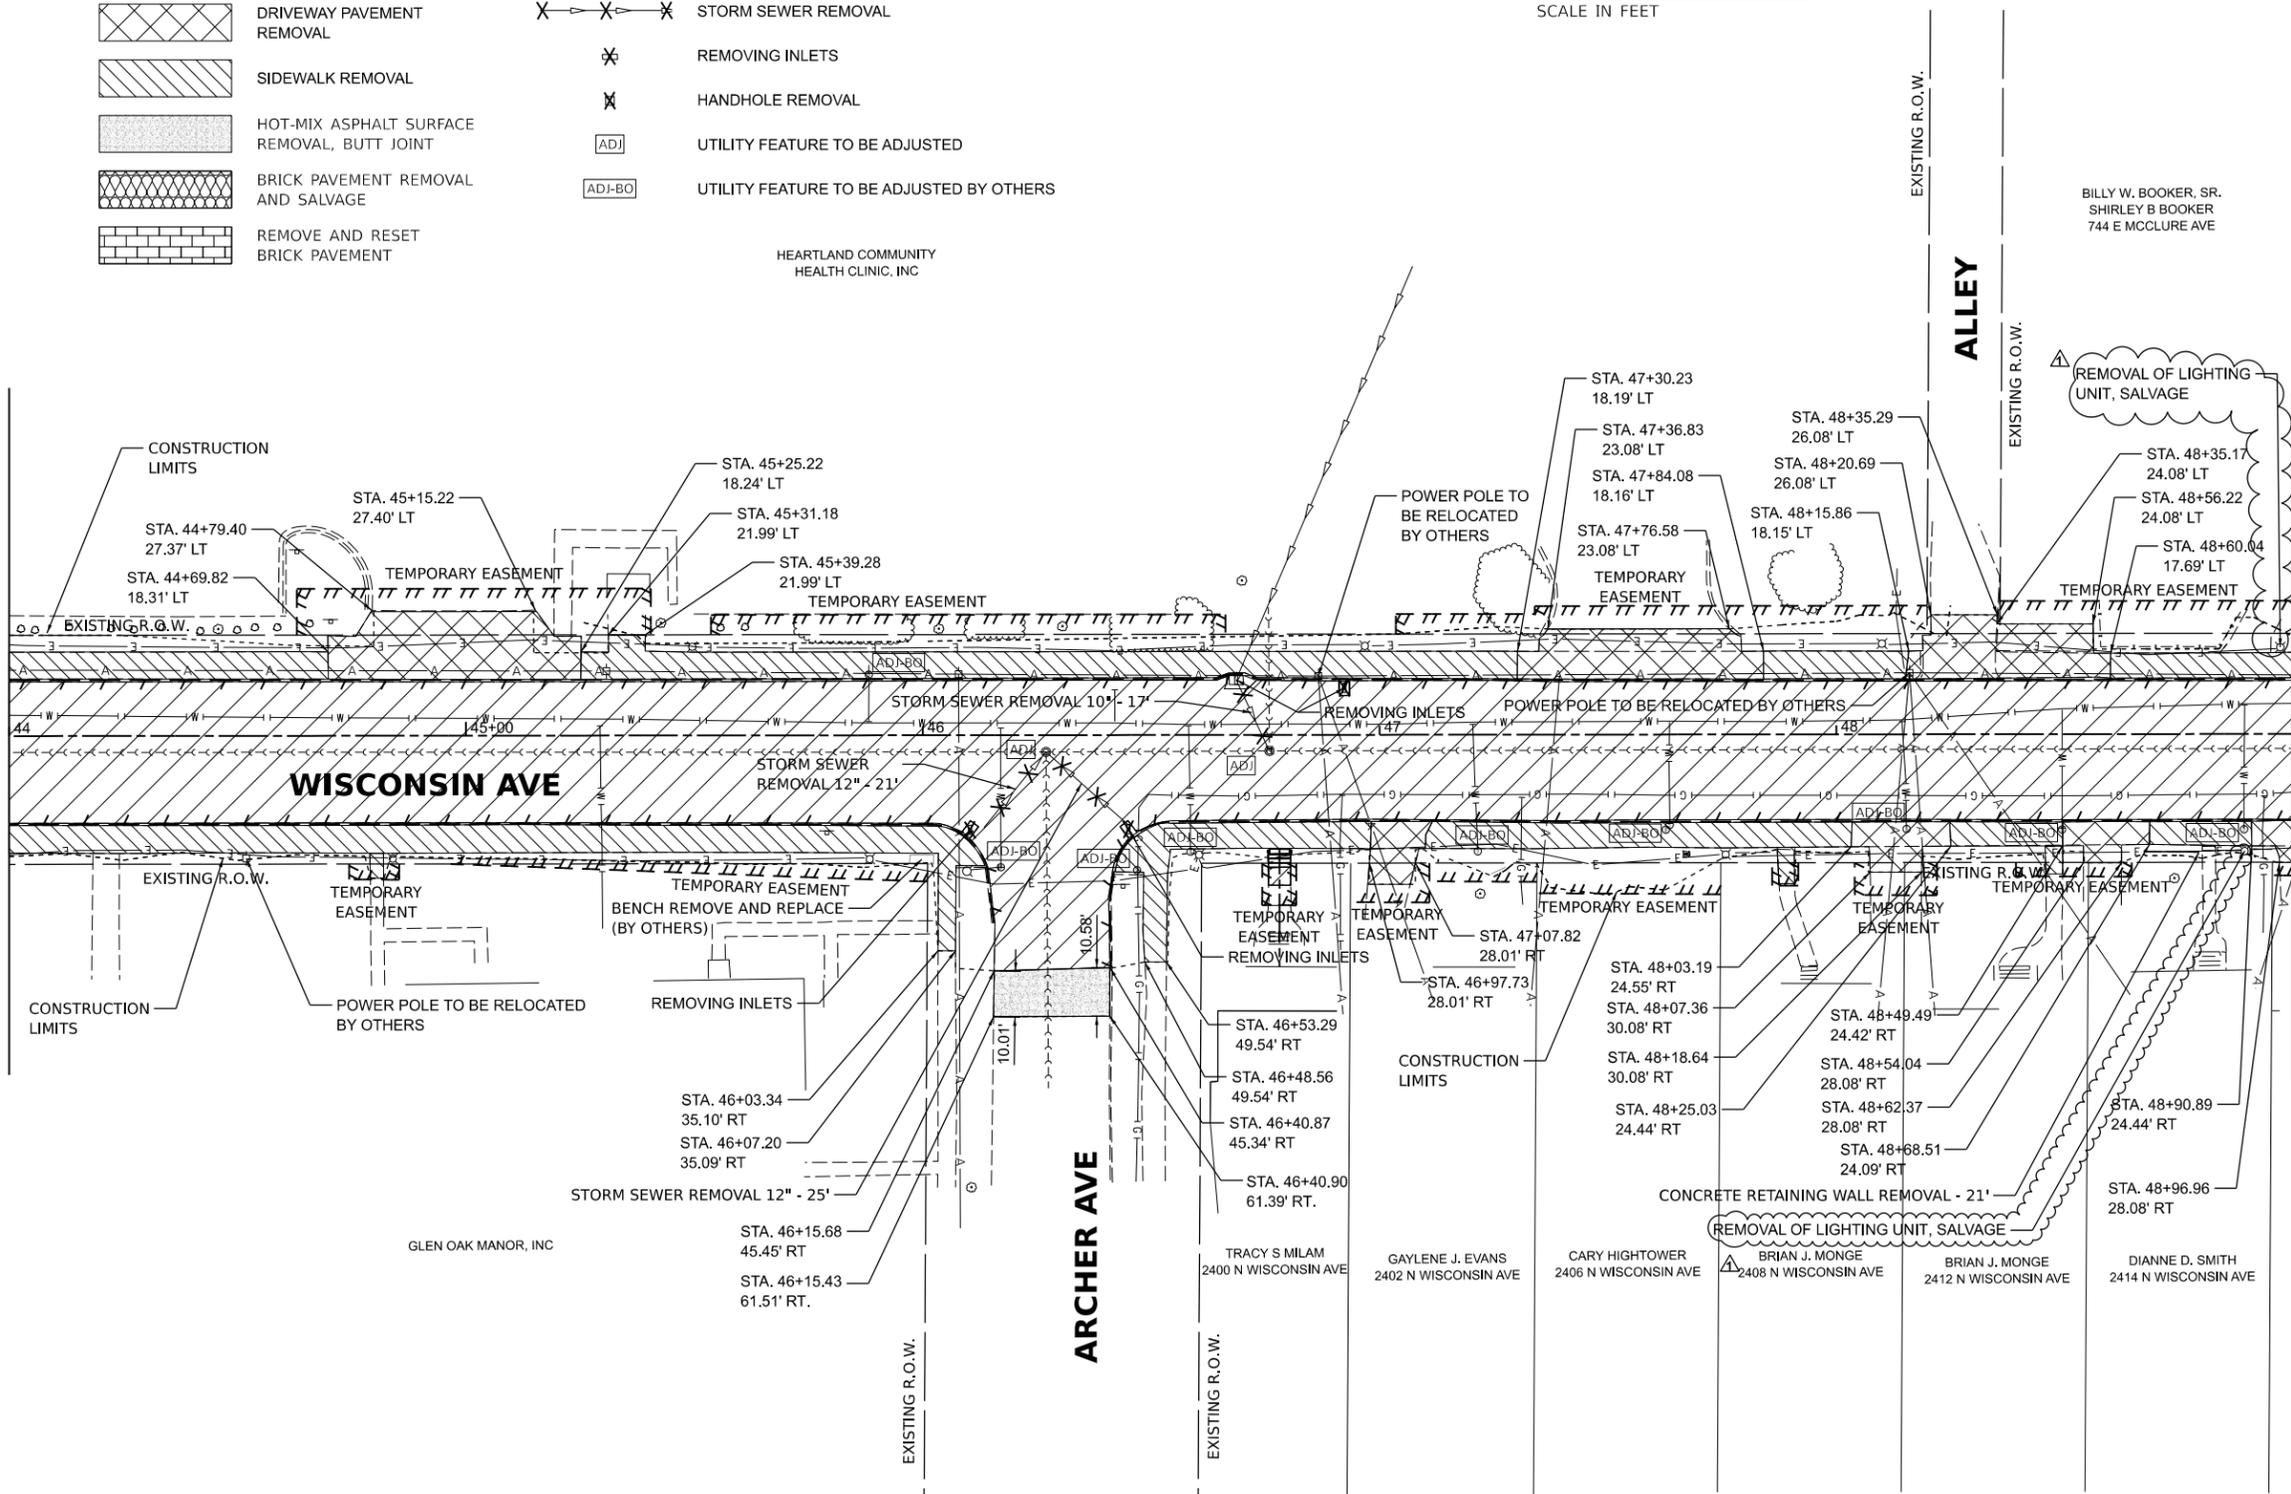

DESIGNED - RSS 12/12/2023 12:00:00 AM  
 DRAWN - JCL 12/12/2023 12:00:00 AM  
 REVIEWED - JFC 1/19/2024 12:00:00 AM

MODEL - 4th-removal.mxd  
 FILE NAME - R23022321.0007\CAD\Road\Sheet\4th-removal.dwg

Final	USER NAME	DESIGNED -	RSS	REVISED -	2/5/2024
	PLOT SCALE	DRAWN -	JCL	REVISED -	
	PLOT DATE	CHECKED -	JFC	REVISED -	
		DATE -	1/19/2024 12:00:00 AM	REVISED -	

**CITY OF PEORIA**

**WISCONSIN AVENUE NEBRASKA TO MCCLURE  
REMOVAL PLANS**





SCALE: 1" = 20' SHEET OF SHEETS STA. TO STA.

F.A.U. RTE.	SECTION	COUNTY	TOTAL SHEETS	SHEET NO.
6599		PEORIA	123	24
23L0007		CONTRACT NO.		
ILLINOIS FED. AID PROJECT				

WATER AND GAS VALVES TO BE ADJUSTED BY OTHERS.

**LIGHTING GENERAL NOTES:**

- EXISTING LIGHT POLE AND FIXTURE TO BE REMOVED, PROTECTED AND RE-INSTALLED IN NEW LOCATION. INTERCEPT EXISTING CONDUIT BELOW GRADE AND RE-ROUTE TO NEW LOCATION. REMOVE INCOMING AND OUTGOING WIRING (IF APPLICABLE) IN EACH POLE TO THE NEXT ACTIVE LIGHT POLE TO REMAIN. REPLACE WIRING COMPLETE. ASSUME 2#10, 1#10G, 2"C. VERIFY AND MATCH EXISTING CONDUIT AND WIRE SIZE IN THE FIELD. MATCH EXISTING CONCRETE FOUNDATION ANCHOR BOLT DIAMETER. PROVIDE AND INSTALL NEW BOLT FASTENERS.
- CONDUIT LOCATIONS SHOWN ARE DIAGRAMMATIC. CONTRACTOR SHALL FIELD VERIFY THE LOCATIONS OF ALL CONDUIT, POWER WIRING AND OTHER ELECTRICAL EQUIPMENT ON SITE. THE DRAWINGS SHOWN ARE BASED ON FIELD DATA AND RECORD DRAWINGS.
- NO DEMOLITION OTHER THAN AS SHOWN IN REMOVAL PLANS SHALL BE PERFORMED TO INSTALL NEW CONDUIT.

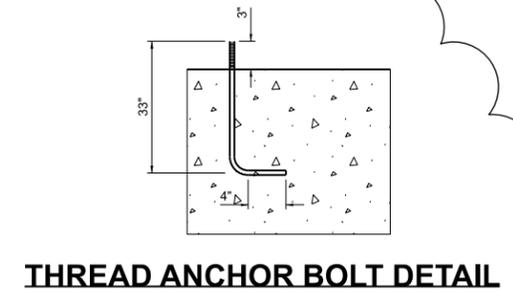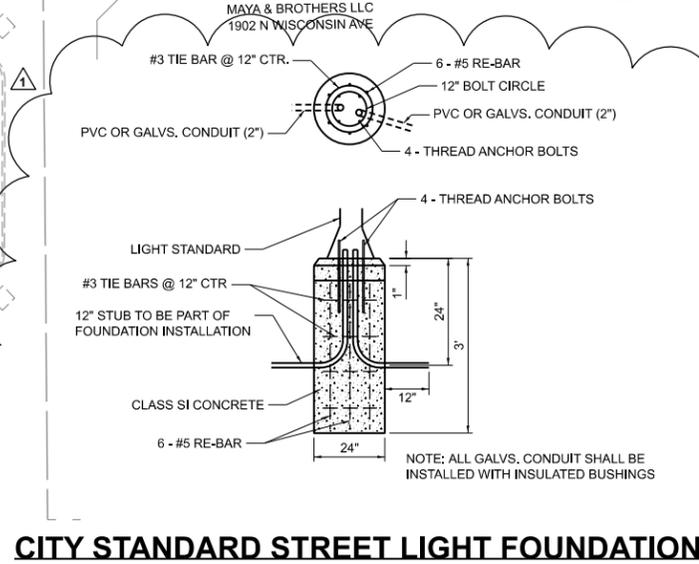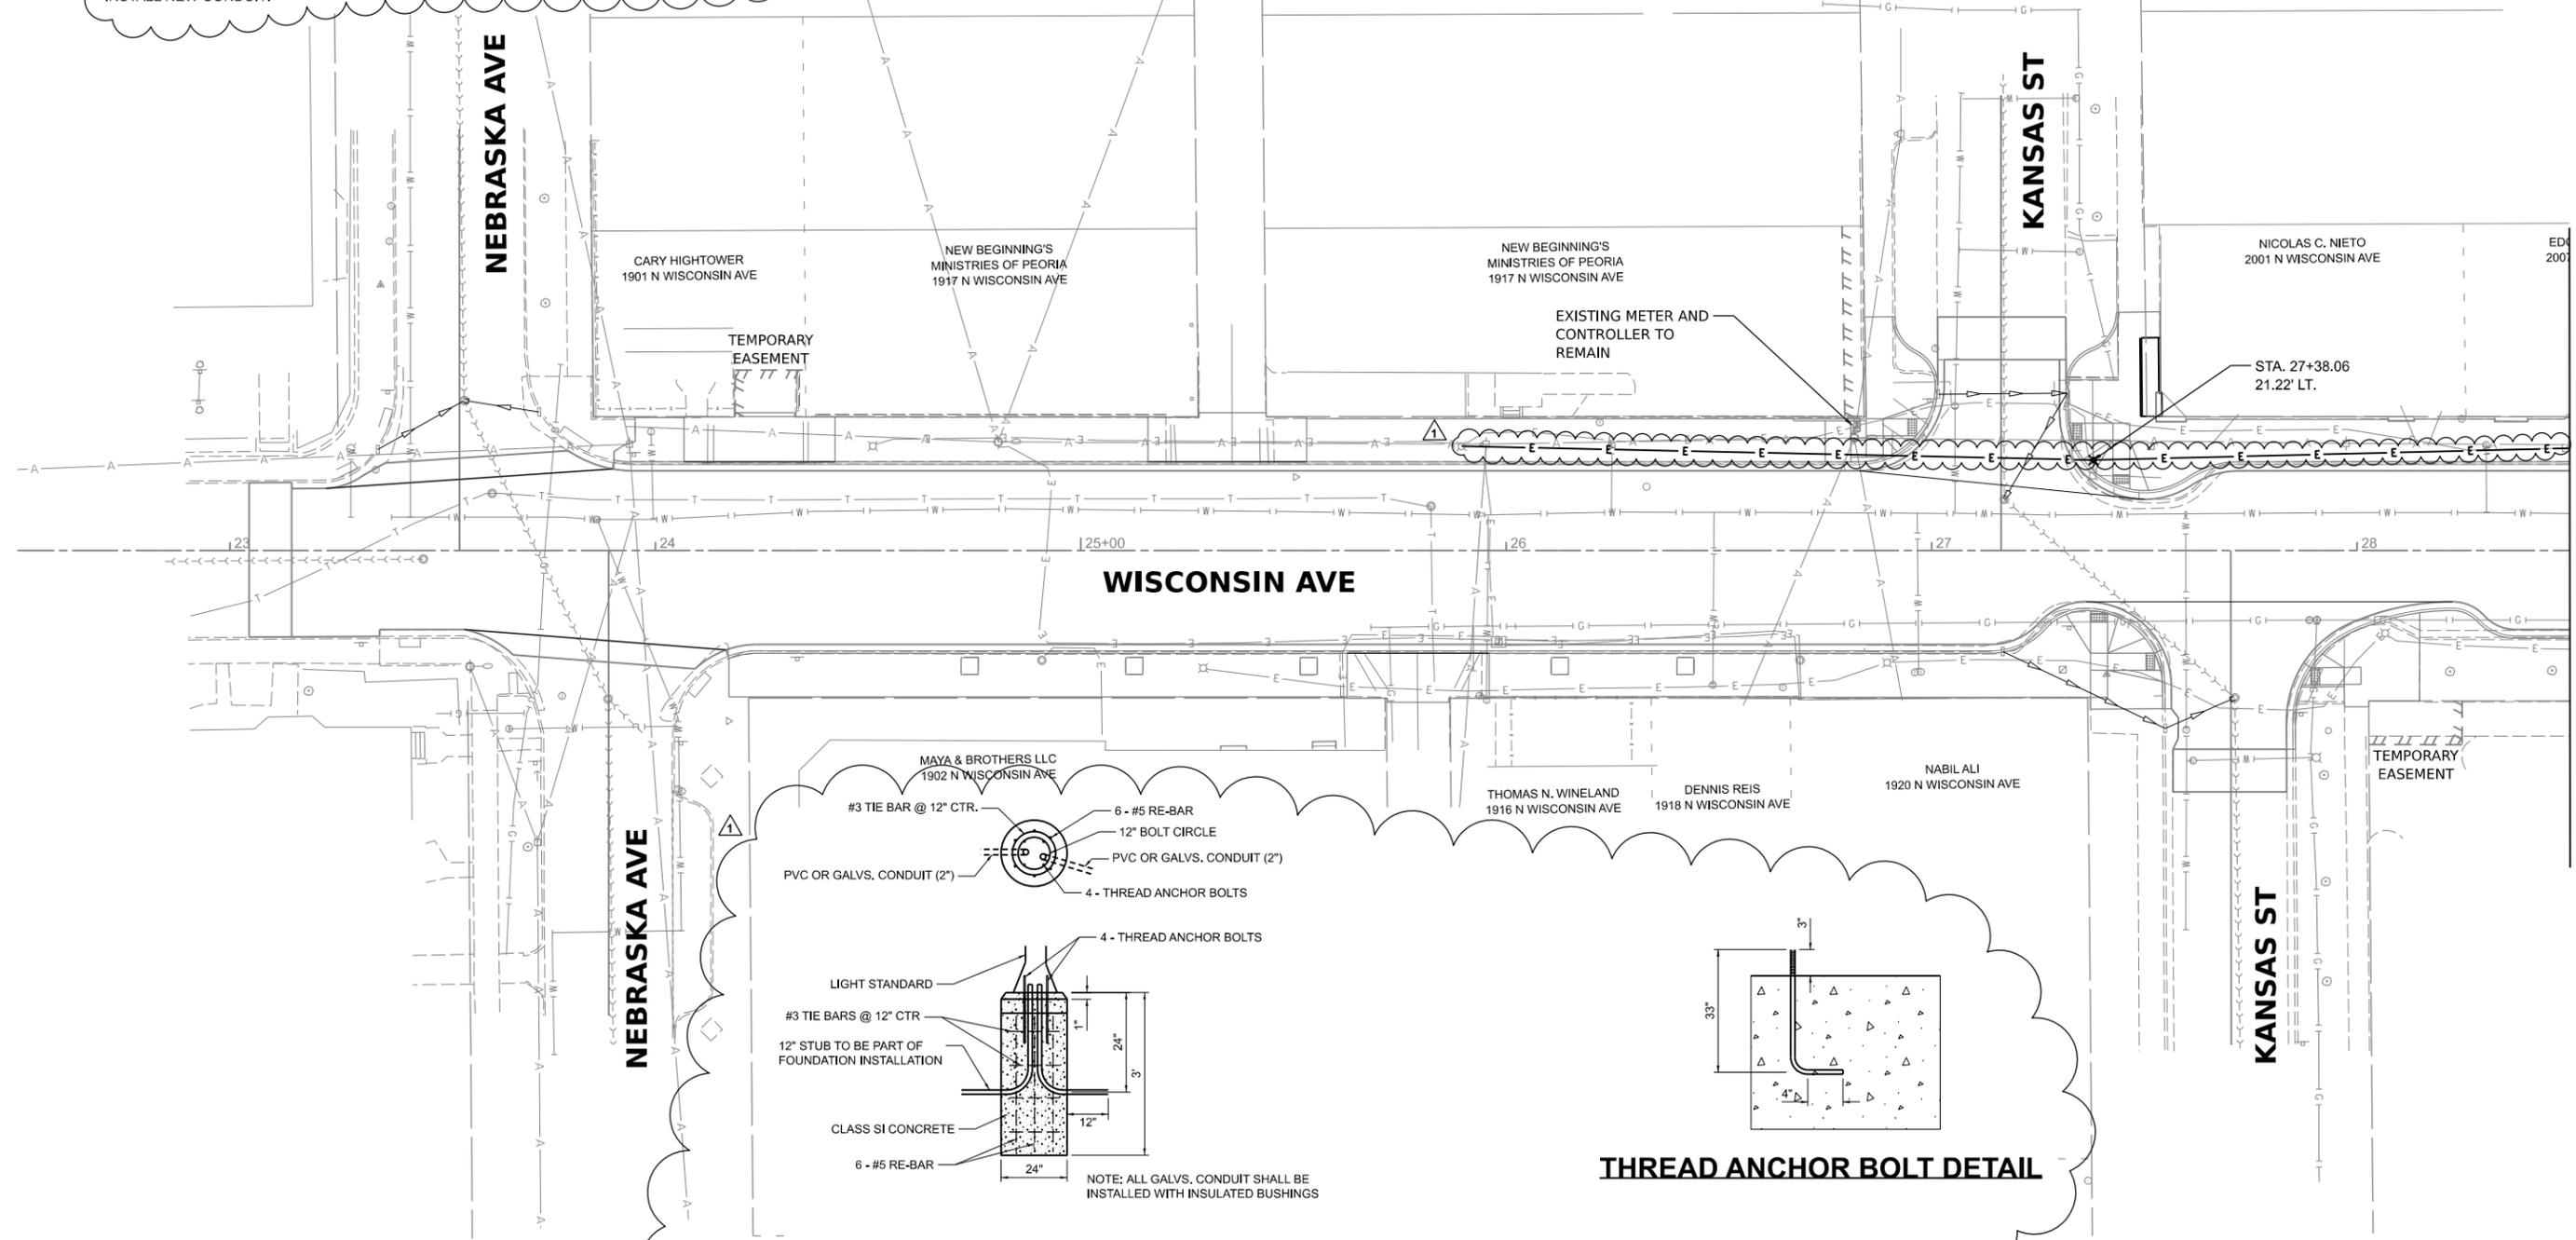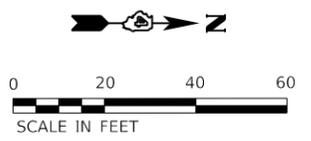

MATCHLINE STA. 28+50.00

DESIGNED - RSS 12/12/2023 12:00:00 AM  
DRAWN - JCL 12/12/2023 12:00:00 AM  
REVIEWED - JFC 1/19/2024 12:00:00 AM

MODEL: Light01  
FILE NAME: R230323120007\_CADD\_Elec\_Sheet\_Sht-Light03.dgn



Final	USER NAME	DESIGNED - RSS	REVISED -  2/5/2024
		DRAWN - JCL	REVISED -
	PLOT SCALE	CHECKED - JFC	REVISED -
	PLOT DATE	DATE - 1/19/2024 12:00:00 AM	REVISED -

**CITY OF PEORIA**

**WISCONSIN AVENUE NEBRASKA TO MCCLURE  
LIGHTING PLANS**

SCALE: 1" = 20' SHEET OF SHEETS STA. TO STA.

F.A.U. RTE. 6599	SECTION 23L0007	COUNTY PEORIA	TOTAL SHEETS 123	SHEET NO. 75
CONTRACT NO.		ILLINOIS FED. AID PROJECT		

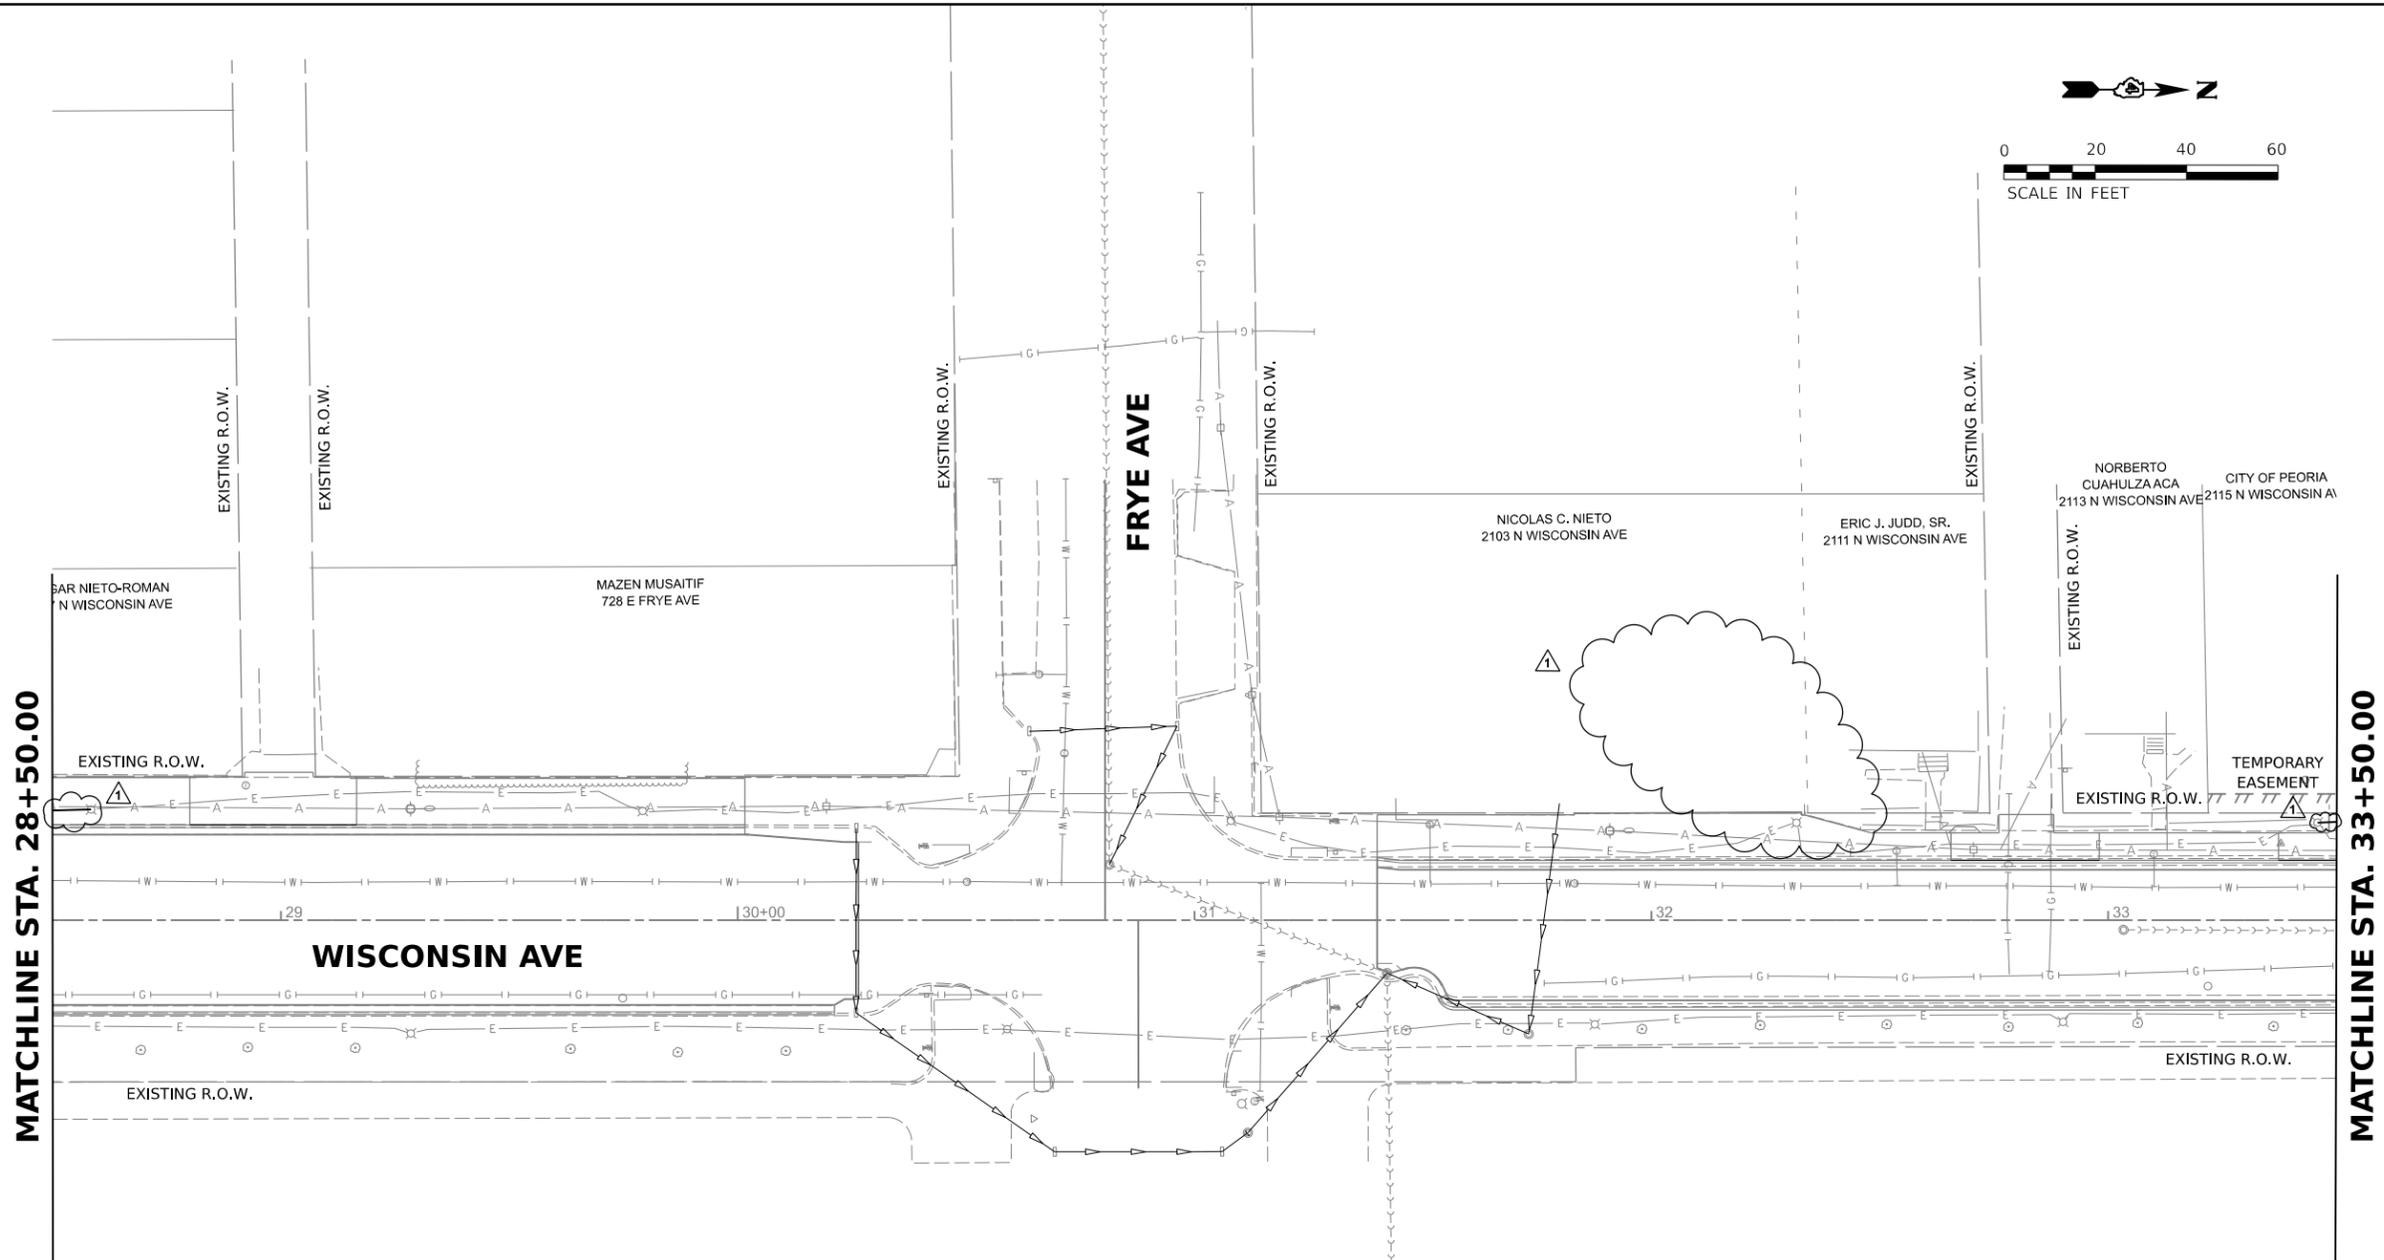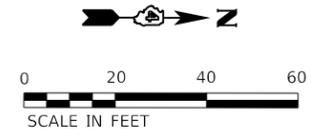

PUBLIC BUILDING  
 COMMISSION OF PEORIA  
 2100 N WISCONSIN AVE



Final	USER NAME	DESIGNED -	RSS	REVISED -	▲ 2/5/2024
		DRAWN -	JCL	REVISED -	
	PLOT SCALE	CHECKED -	JFC	REVISED -	
	PLOT DATE	DATE -	1/19/2024 12:00:00 AM	REVISED -	

**CITY OF PEORIA**

**WISCONSIN AVENUE NEBRASKA TO MCCLURE  
 LIGHTING PLANS**

SCALE: 1" = 20' SHEET OF SHEETS STA. TO STA.

F.A.U. RTE.	SECTION	COUNTY	TOTAL SHEETS	SHEET NO.
6599		PEORIA	123	76
23L0007		CONTRACT NO.		
ILLINOIS FED. AID PROJECT				

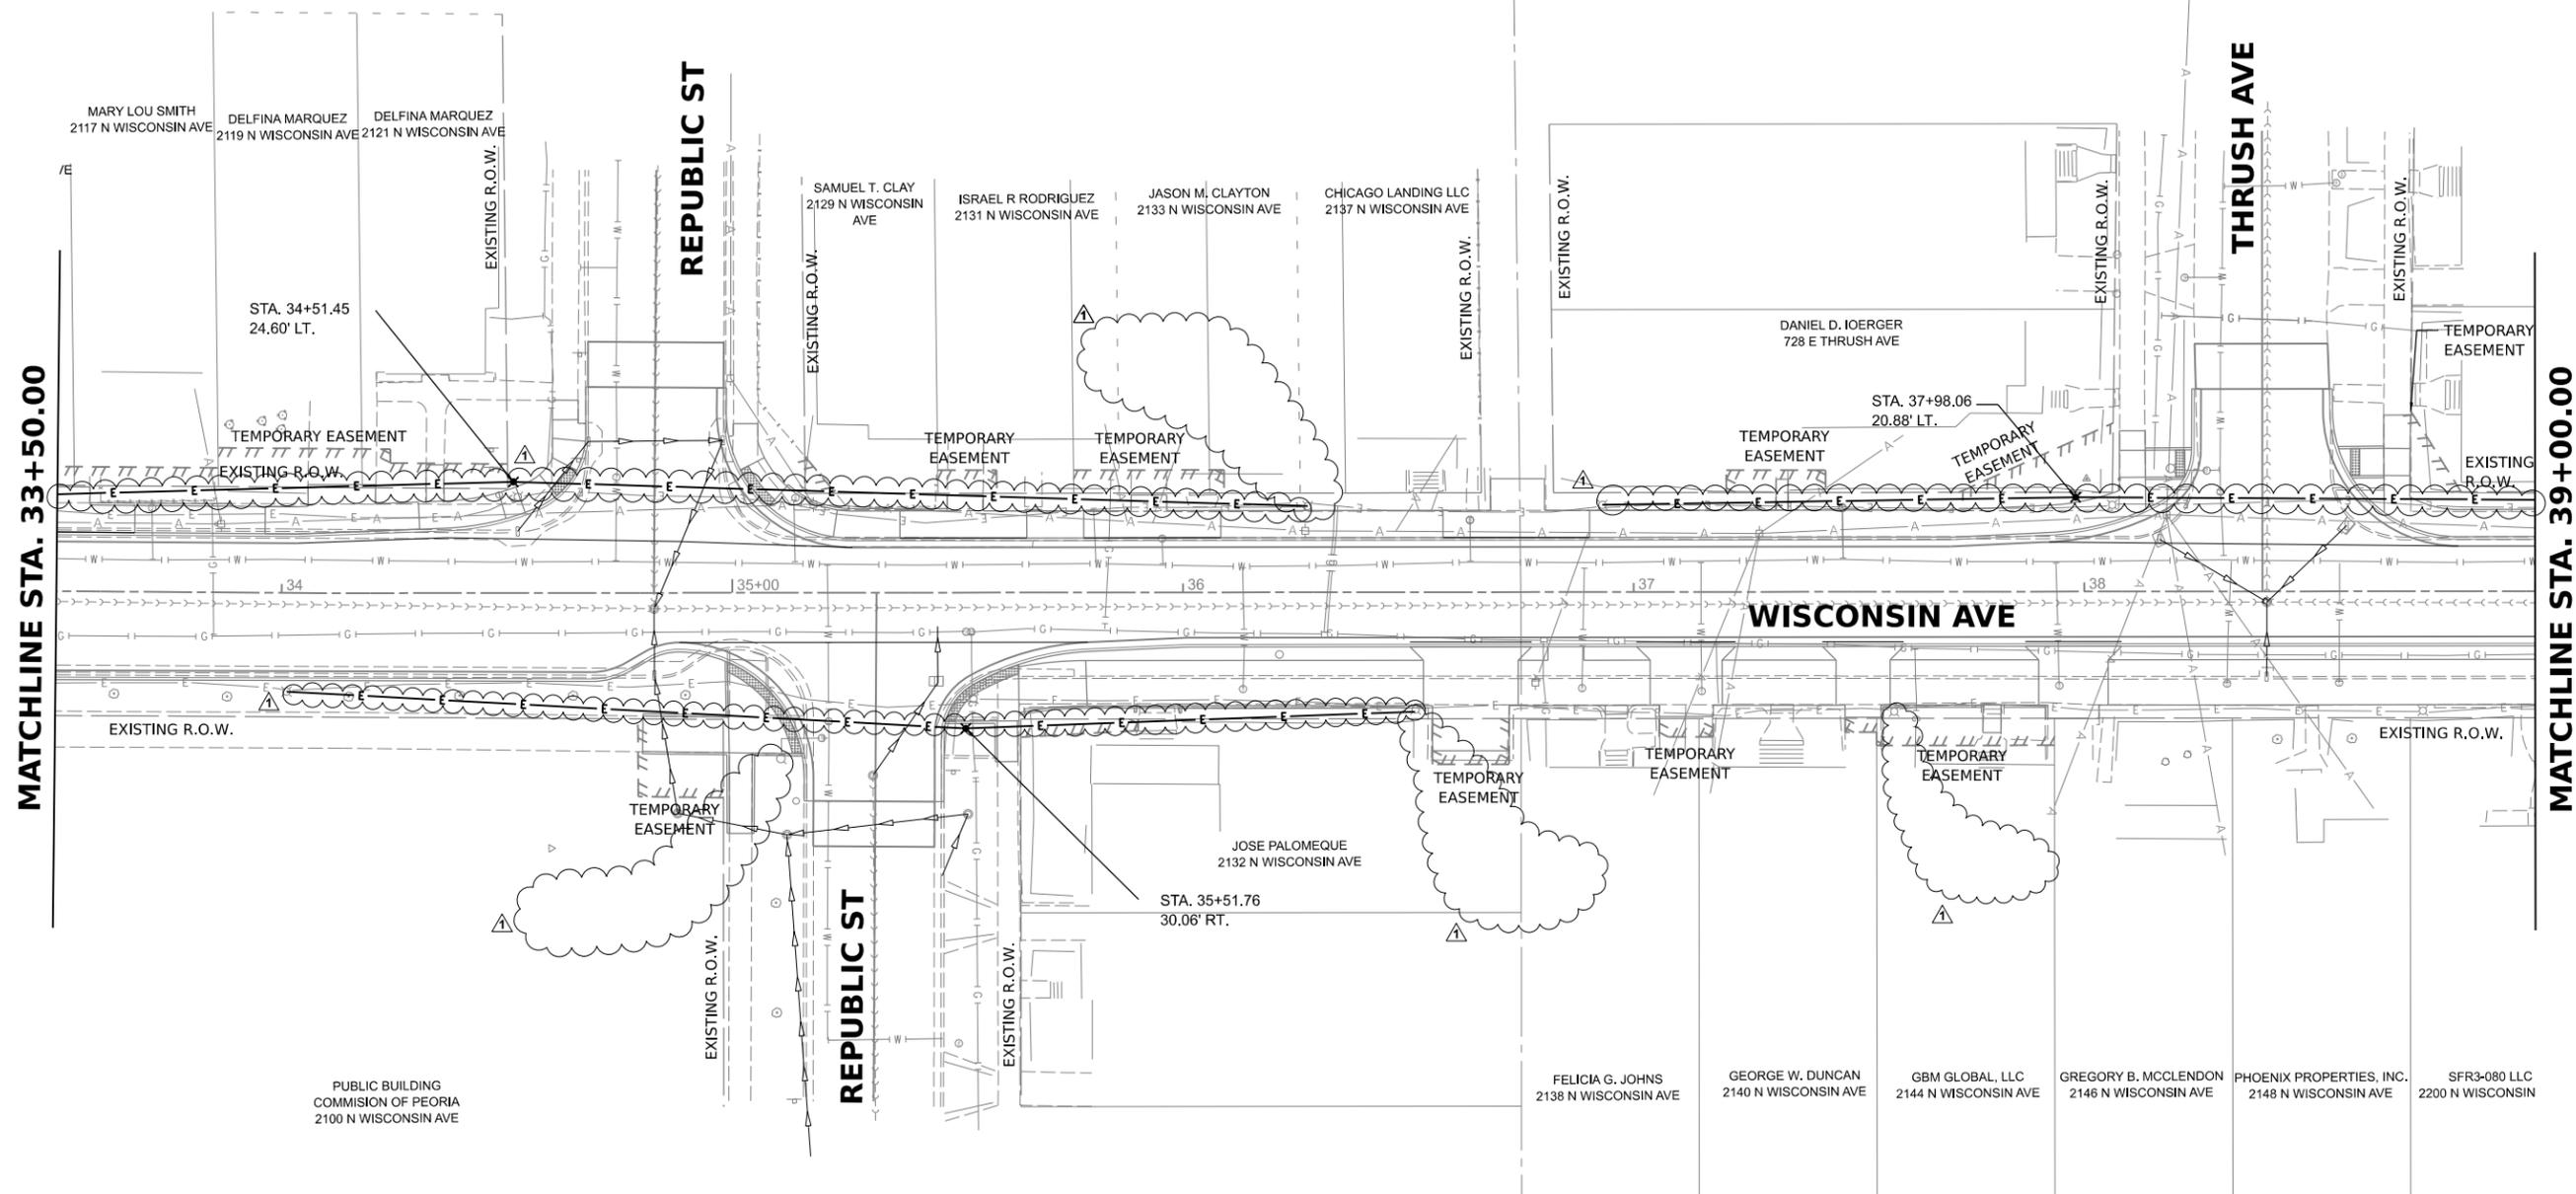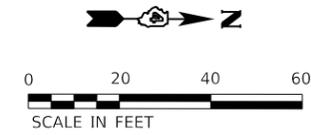

DESIGNED - RSS 12/12/2023 12:00:00 AM  
 DRAWN - JCL 12/12/2023 12:00:00 AM  
 REVIEWED - JFC 1/19/2024 12:00:00 AM

MODEL - Light03  
 FILE NAME - R230323\23.0007\CADD\Elec\Sheet\Light03.dgn


Final	USER NAME	DESIGNED -	RSS	REVISED -	2/5/2024
	PLOT SCALE	DRAWN -	JCL	REVISED -	
	PLOT DATE	CHECKED -	JFC	REVISED -	
		DATE -	1/19/2024 12:00:00 AM	REVISED -	

**CITY OF PEORIA**

**WISCONSIN AVENUE NEBRASKA TO MCCLURE LIGHTING PLANS**


SCALE: 1" = 20' SHEET OF SHEETS STA. TO STA.

F.A.U. RTE.	SECTION	COUNTY	TOTAL SHEETS	SHEET NO.
6599		PEORIA	123	77
23L0007		CONTRACT NO.		
		ILLINOIS FED. AID PROJECT		

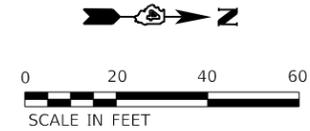

MATCHLINE STA. 39+00.00

MATCHLINE STA. 44+00.00

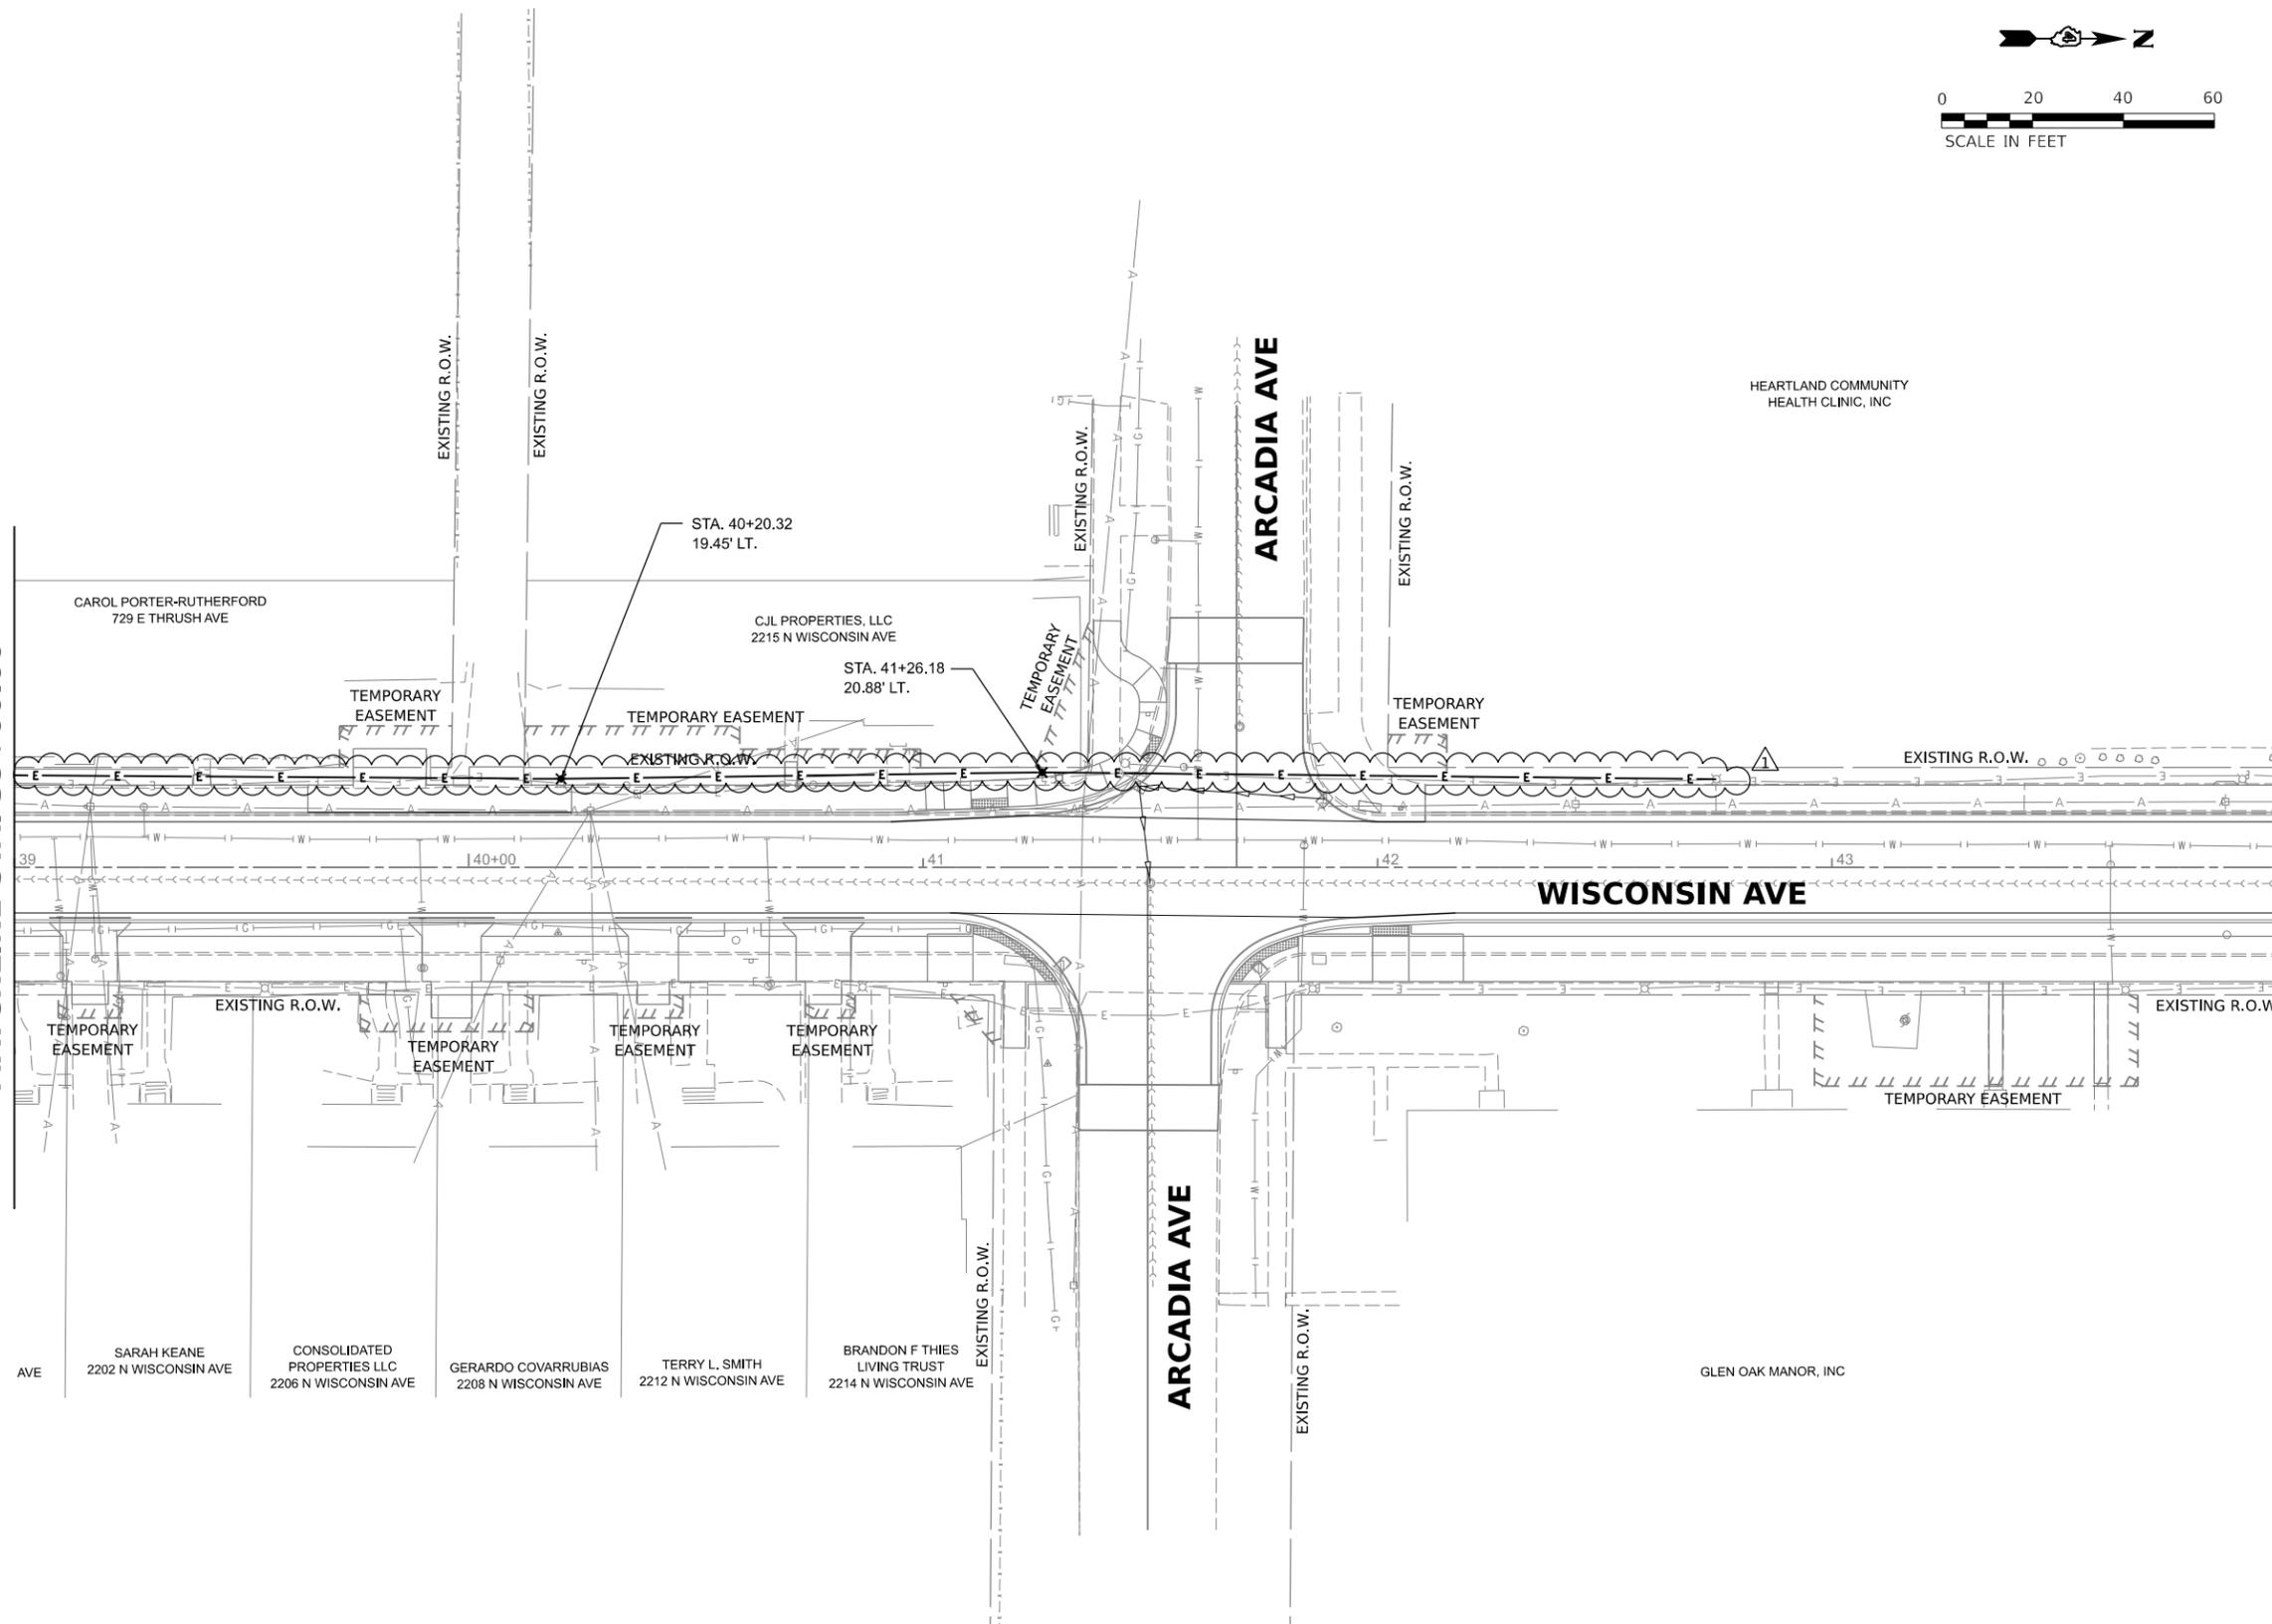

DESIGNED - RSS 12/12/2023 12:00:00 AM  
 DRAWN - JCL 12/12/2023 12:00:00 AM  
 REVIEWED - JFC 1/19/2024 12:00:00 AM

MODEL: Light04  
 FILE NAME: E:\230323\23L0007\CADD\Elec\Sheet\Light04.dgn


Final	USER NAME	DESIGNED - RSS	REVISED -  2/5/2024
		DRAWN - JCL	REVISED -
	PLOT SCALE	CHECKED - JFC	REVISED -
	PLOT DATE	DATE - 1/19/2024 12:00:00 AM	REVISED -

**CITY OF PEORIA**

**WISCONSIN AVENUE NEBRASKA TO MCCLURE  
 LIGHTING PLANS**


SCALE: 1" = 20' SHEET OF SHEETS STA. TO STA.

F.A.U. RTE. 6599	SECTION 23L0007	COUNTY PEORIA	TOTAL SHEETS 123	SHEET NO. 78
		CONTRACT NO.		
		ILLINOIS FED. AID PROJECT		

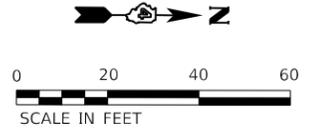

MATCHLINE STA. 44+00.00

MATCHLINE STA. 49+00.00

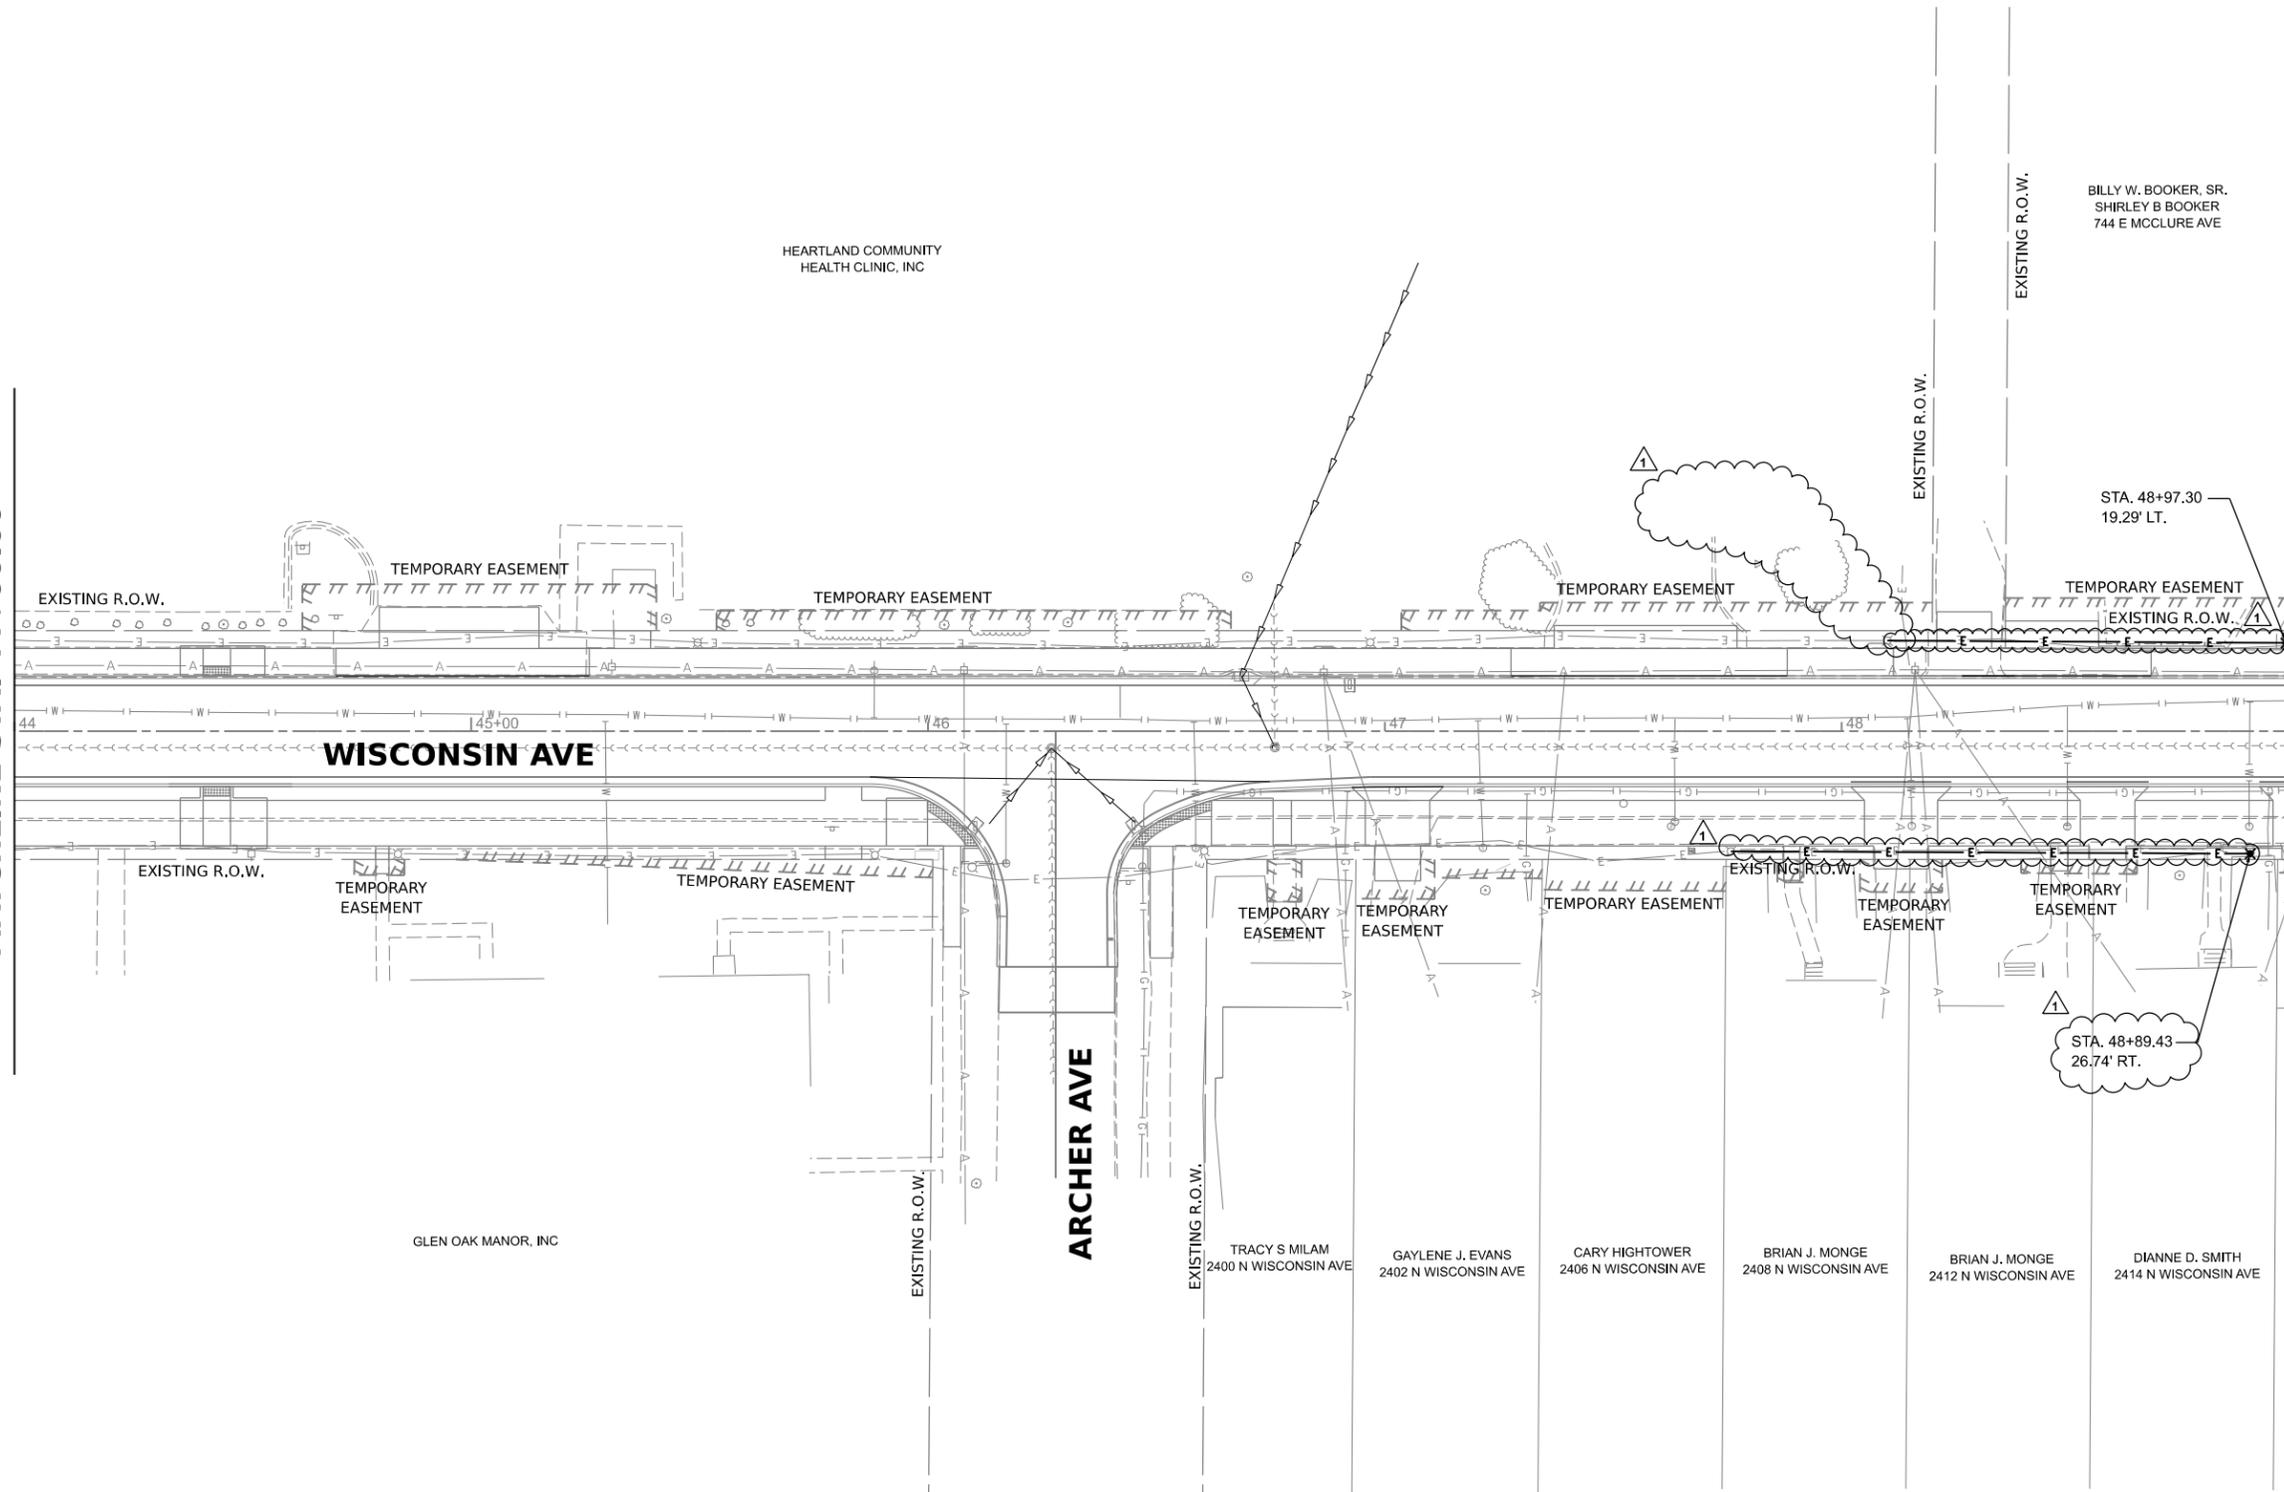

DESIGNED - RSS 12/12/2023 12:00:00 AM  
 DRAWN - JCL 12/12/2023 12:00:00 AM  
 REVIEWED - JFC 1/19/2024 12:00:00 AM

MODEL: Light05  
 FILE NAME: R230323\23.0007\CADD\Elec\Sheet\Light05.dgn

Final	USER NAME	DESIGNED -	RSS	REVISED -	2/5/2024
		DRAWN -	JCL	REVISED -	
	PLOT SCALE	CHECKED -	JFC	REVISED -	
	PLOT DATE	DATE -	1/19/2024 12:00:00 AM	REVISED -	


**CITY OF PEORIA**

**WISCONSIN AVENUE NEBRASKA TO MCCLURE  
 LIGHTING PLANS**


SCALE: 1" = 20' SHEET OF SHEETS STA. TO STA.

F.A.U. RTE.	SECTION	COUNTY	TOTAL SHEETS	SHEET NO.
6599		PEORIA	123	79
23L0007		CONTRACT NO.		
ILLINOIS FED. AID PROJECT				

NOTE:  
 LIGHT POLE ON THIS SHEET IS ON A DIFFERENT CIRCUIT THAN ALL OTHER LIGHT POLES.  
 LOCATE EXISTING CONDUIT AND WIRES AND REPLACE TO THE ADJACENT EXISTING POLES  
 ON THIS CIRCUIT PER LIGHTING GENERAL NOTES. ASSUMED TOTAL DISTANCE TO EXISTING  
 POLES IS 500 FT.

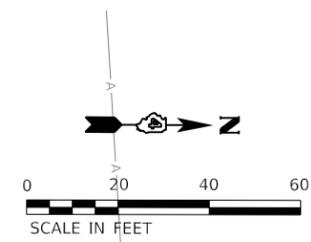

MATCHLINE STA. 49+00.00

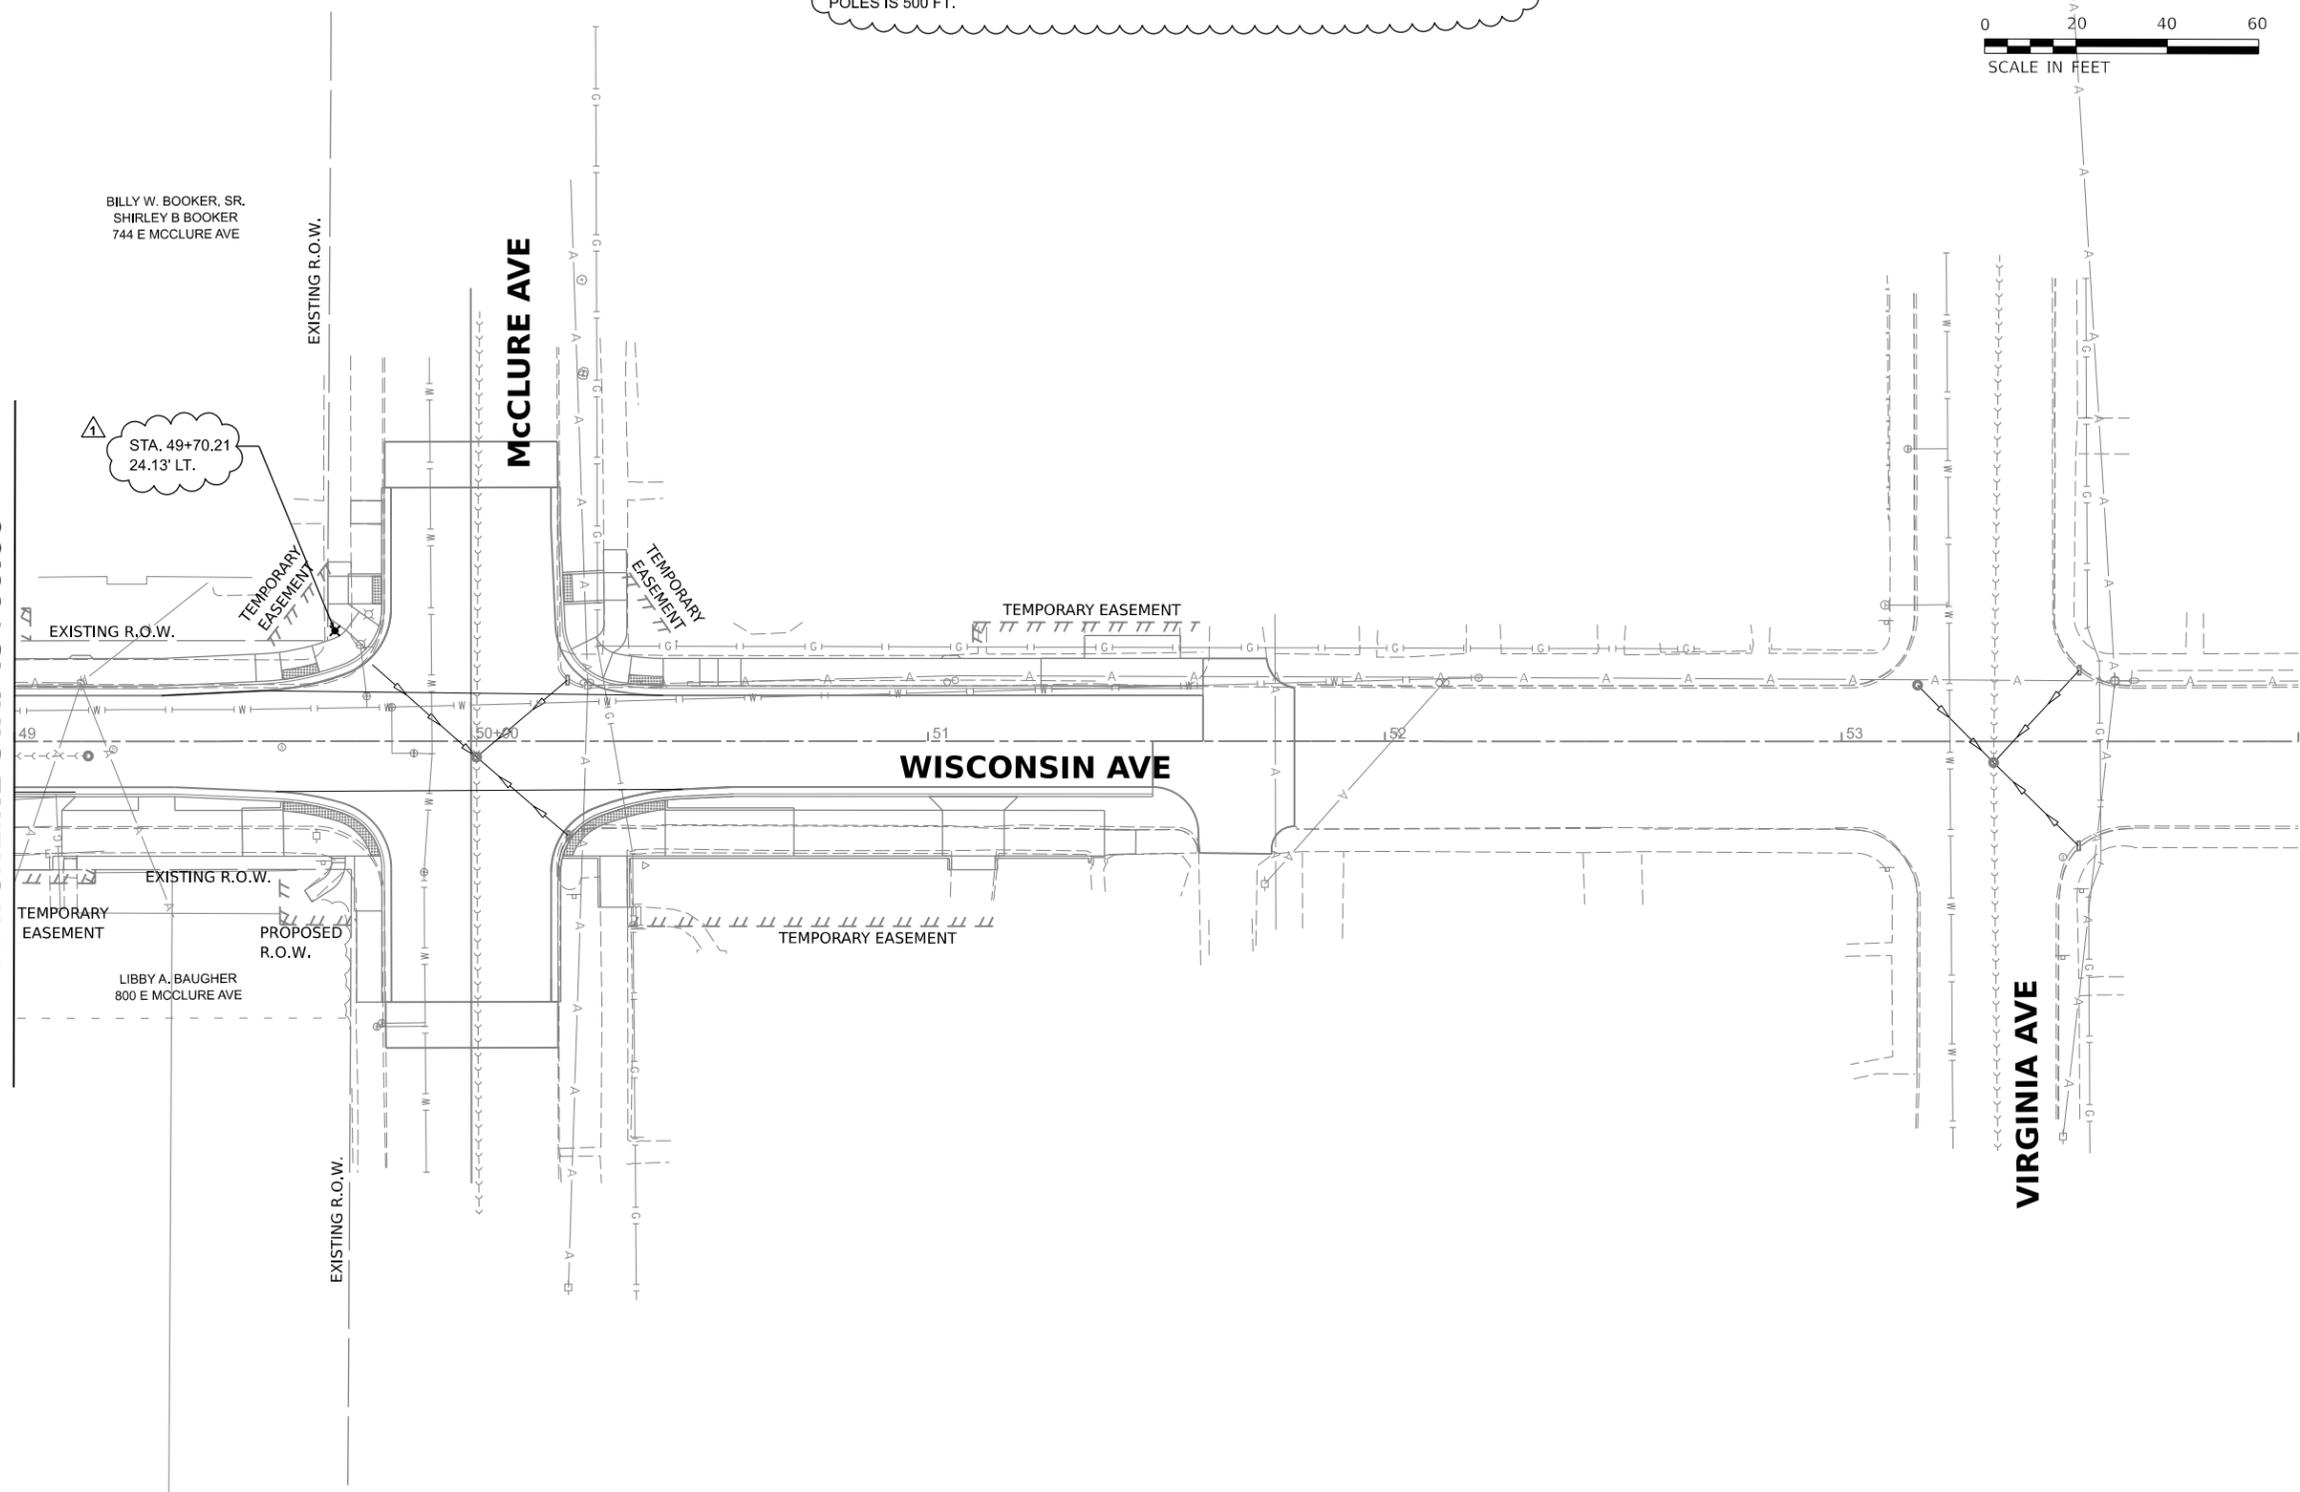

Final

USER NAME	DESIGNED - RSS	REVISED -  2/5/2024
	DRAWN - JCL	REVISED -
PLOT SCALE	CHECKED - JFC	REVISED -
PLOT DATE	DATE - 1/19/2024 12:00:00 AM	REVISED -

CITY OF PEORIA

**WISCONSIN AVENUE NEBRASKA TO MCCLURE  
 LIGHTING PLANS**

SCALE: 1" = 20' SHEET OF SHEETS STA. TO STA.

F.A.U. RTE. 6599	SECTION 23L0007	COUNTY PEORIA	TOTAL SHEETS 123	SHEET NO. 80
CONTRACT NO.		ILLINOIS FED. AID PROJECT		

**PROPOSAL BID FORM**

Equal Opportunity Manager  
[ooo@peoriagov.org](mailto:ooo@peoriagov.org)  
 (309) 494-8530

The Fifty-dollar (\$50.00) processing fee can be paid by check, payable to the City of Peoria, or online through the State of Illinois E-Pay process. To pay online go to [www.illinoisepay.com](http://www.illinoisepay.com) and follow the instructions. The only exception to payment of the processing fee is neighborhood associations.

**Although all vendors are encouraged to obtain an EEO Certification Number, you do not need a number to respond to a bid. The number is only required prior to the award of a contract.**

EEO CERTIFICATION\* (Check one):

- We are presently applying for the EEO Certification. Employer Report Form (Form CC-1) is completed and enclosed.
- Presently, we have the Employer Report Form (Form CC-1) on file with the City of Peoria, Office of Equal Opportunity and have a current Certificate of Compliance Number.

Certificate of Compliance Number: \_\_\_\_\_

**ARTICLE 5 – BASIS OF BID**

5.01 Bidder has received the Excel file of the bid items provided by the City. The Excel file is provided as a convenience for the bidder, but the Bid Sheet in the formal bid package shall control. Bidder shall be responsible for providing a fully responsive bid and hereby waives any responsibility of the City for any discrepancies in the Excel file. The bid items and quantities below are the official Bid items for the project.

Signature \_\_\_\_\_ Date \_\_\_\_\_

5.02 Base Bid: Bidder will complete the work in accordance with the contract documents for the following price(s):

Item	Description	Quantity	Unit	Unit Price	Amount
20101100	TREE TRUNK PROTECTION	23	EACH		
20200100	EARTH EXCAVATION	4,445	CU YD		
20201200	REM & DISP UNS MATL	722	CU YD		
21000300	GRAN EMBANK SPEC	1,481	TON		
21001000	GEOTECH FAB F/GR STAB	2,168	SQ YD		
21101615	TOPSOIL F & P 4	1,620	SQ YD		
21101620	TOPSOIL F & P 5	9	SQ YD		
25000400	NITROGEN FERT NUTR	20	POUND		
25000500	PHOSPHORUS FERT NUTR	20	POUND		

1

**PROPOSAL BID FORM**

25000600	POTASSIUM FERT NUTR	20	POUND		
25200110	SODDING SALT TOLERANT	1,620	SQ YD		
25200200	SUPPLE WATERING	20	UNIT		
28000400	PERIMETER EROS BAR	33	FOOT		
28000510	INLET FILTERS	65	EACH		
31100910	SUB GRAN MAT A 12	10,841	SQ YD		
31101200	SUB GRAN MAT B 4	4,729	SQ YD		
40201000	AGGREGATE-TEMP ACCESS	500	TON		
40600295	P BIT MATLS TACK CT	2,321	POUND		
40600982	HMA SURF REM BUTT JT	510	SQ YD		
40604160	P HMA SC IL-9.5 D N50	1,098	TON		
42000205	PCC PVT 7 1/4	9,294	SQ YD		
42001300	PROTECTIVE COAT	6,303	SQ YD		
42300200	PCC DRIVEWAY PAVT 6	677	SQ YD		
42300400	PCC DRIVEWAY PAVT 8	295	SQ YD		
42400100	PC CONC SIDEWALK 4	32,515	SQ FT		
42400800	DETECTABLE WARNINGS	561	SQ FT		
44000100	PAVEMENT REM	10,987	SQ YD		
44000200	DRIVE PAVEMENT REM	791	SQ YD		
44000500	COMB CURB GUTTER REM	5,357	FOOT		
44000600	SIDEWALK REM	28,020	SQ FT		
550A0050	STORM SEW CL A 1 12	215	FOOT		
550A0070	STORM SEW CL A 1 15	22	FOOT		
550A0450	STORM SEW CL A 2 36	690	FOOT		
550A0470	STORM SEW CL A 2 42	155	FOOT		
55100400	STORM SEWER REM 10	47	FOOT		
55100500	STORM SEWER REM 12	300	FOOT		
55100900	STORM SEWER REM 18	21	FOOT		
59300100	CONTR LOW-STRENG MATL	994	CU YD		
60240220	INLETS TB T3F&G	32	EACH		
60218300	MAN TA 4 DIA T1F OL	2	EACH		
60218500	MAN TA 4 DIA T3F&G	4	EACH		
60221100	MAN TA 5 DIA T1F CL	3	EACH		
60223700	MAN TA 6 DIA T1F OL	2	EACH		
60223800	MAN TA 6 DIA T1F CL	11	EACH		
60260100	INLETS ADJUST	1	EACH		
60260400	INLETS ADJ NEW T1F CL	1	EACH		
60500060	REMOV INLETS	16	EACH		
60600605	CONC CURB TB	42	FOOT		
60604400	COMB CC&G TB6.18	5,374	FOOT		
67100100	MOBILIZATION	1	L SUM		

**PROPOSAL BID FORM**

Item	Description	Quantity	Unit	Unit Price	Amount
70107025	CHANGEABLE MESSAGE SN	70	CAL DA		
70306120	TMP PVT MK L4 T3 TAPE	8,900	FOOT		
70306210	TMP PVT MK L24 T3 TAP	900	FOOT		
72400310	REMOV SIGN PANEL T1	406	SQ FT		
78009004	MOD URETH PM LINE 4	2,875	FOOT		
78009008	MOD URETH PM LINE 8	2,513	FOOT		
78009024	MOD URETH PM LINE 24	223	FOOT		
81028350	UNDRGRD C PVC 2	350	FOOT		
81702110	EC C XLP USE 1C 10	6,849	FOOT		
83600200	LIGHT POLE FDN 24D	27	FOOT		
84200500	REM LT UNIT SALV	9	EACH		
K1005481	SHRED BARK MULCH 3	93	SQ YD		
Z0012455	CONC STEP REMOV	10	EACH		
Z0013798	CONSTRUCTION LAYOUT	1	L SUM		
Z0016702	DETOUR SIGNING	1	L SUM		
Z0019500	DRYWELL	4	EACH		
Z0042300	PC CONC SIDEWALK CURB	188	FOOT		
Z0056646	SS 1 WAT MN 10	30	FOOT		
Z0056648	SS 1 WAT MN 12	845	FOOT		
Z0075496	CONC RETAIN WALL REM	168	FOOT		
Z0076600	TRAINEES	1,000	HOUR	\$0.80	\$800.00
Z0076604	TRAINEES TPG	1,000	HOUR	\$15.00	\$15,000.00
X5220102	RETAINING WALL REMOV	80	FOOT		
X6020082	INLETS TG-1	10	EACH		
X6026200	INLETS ADJUST SPL	3	EACH		
X6021814	INL-MN G-1 4D	1	EACH		
X6026050	SANITARY MANHOLE ADJ	13	EACH		
X7010216	TRAF CONT & PROT SPL	1	L SUM		
X8140115	HANDHOLE TO BE ADJUST	2	EACH		
XX000300	CONCRETE STEPS	55	SQ FT		
XX005565	REM AND RES BRICK PAV	307	SQ FT		
XX006498	COMB C C&SIDEWLK 4 SP	1,287	SQ FT		
XX006751	STAIR RAILING	37	FOOT		
XX009234	BRICK PAVT REM & SALV	656	SQ YD		
PEO00001	ACCESSIBLE RAMP SYSTEM, SPECIAL	1	EACH		
<b>Total Base Bid Amount</b>					

in writing \_\_\_\_\_